

ZONED-CENTRAL BUILDING


N. FEDERAL HWY (NE 6th AVE.)

BUILDING III


BUILDING I

BUILDING I

BUIL

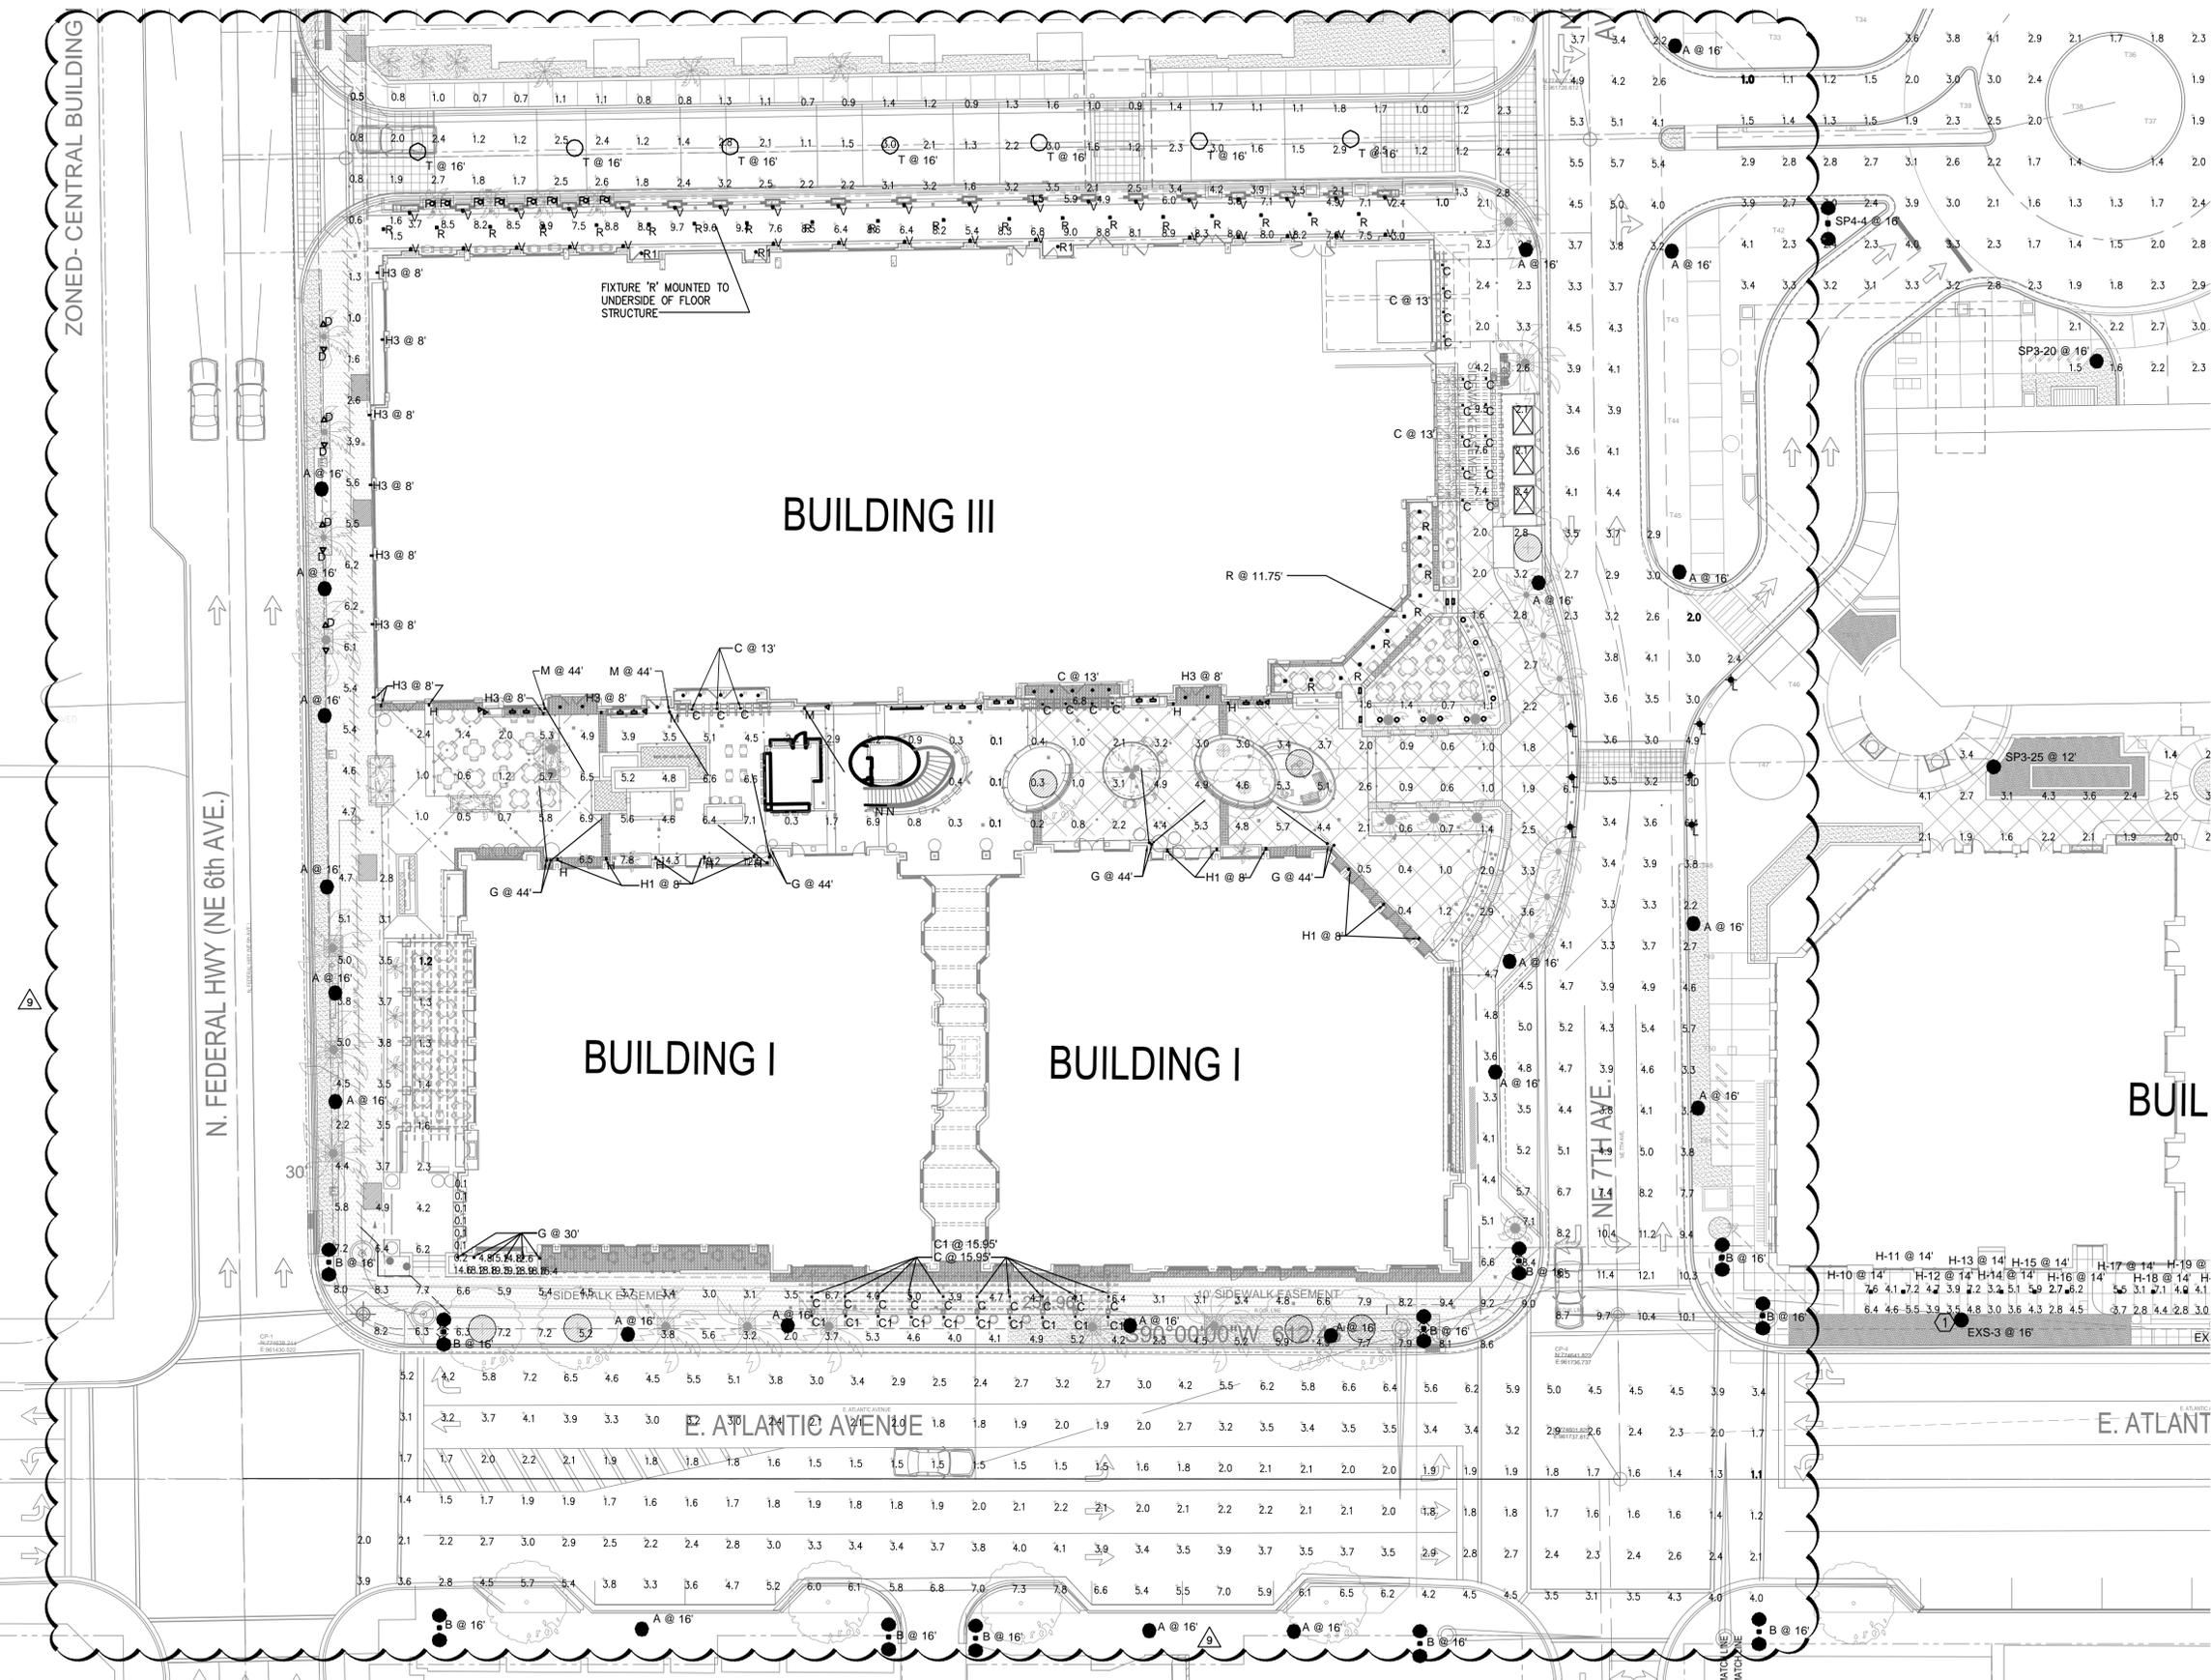


- KEY NOTES:
- ① EXISTING CITY LIGHT POLE SHALL BE REPLACED WITH NEW CITY STANDARD LED LIGHT POLE (ACORN STYLE)
  - ② EXISTING CITY LIGHT POLE SHALL BE REMOVED.

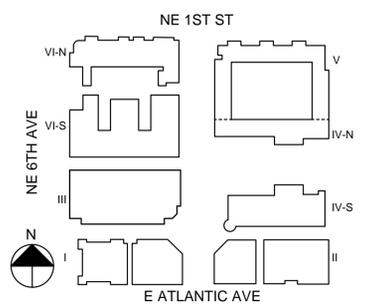

**KEPHART**  
community ■ planning ■ architecture  
COPYRIGHT © 2013

# Atlantic Crossing

Project Number: 212006

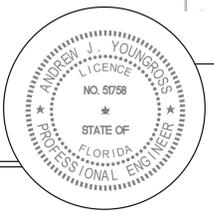

#	DATE:	ISSUE / REVISIONS:
	09-17-13	RESPONSE TO STAFF COMMENTS
	10-29-13	10/18 STAFF RESPONSE
1	11-14-14	RESPONSE TO 2,12,14 STAFF COMMENTS
2	11-17-15	STAFF COMMENTS
3	12-21-15	STAFF COMMENTS
4	01-12-16	STAFF COMMENTS
5	02-24-16	STAFF COMMENTS
6	04-21-17	SETTLEMENT MODIFICATION
7	05-10-17	RESPONSE TO STAFF COMMENTS
8	05-20-19	SPRAB RE-SUBMITTAL
9	07-17-20	SPRAB RE-SUBMITTAL

**TYCO** THOMPSON & YOUNGROSS  
ENGINEERING CONSULTANTS, LLC  
CERTIFICATE OF AUTHORIZATION  
NO. 25998  
902 CLINT MOORE ROAD, SUITE 142  
BOCA RATON, FLORIDA, 33487  
www.tyco.com  
561-274-0200  
561-274-0222

## PARTIAL SITE PLAN -PHOTOMETRICS

DRAWN BY: AJY

SCALE: 1" = 20'

SHEET NUMBER

# ES1.1

DATE: 06.18.2013