
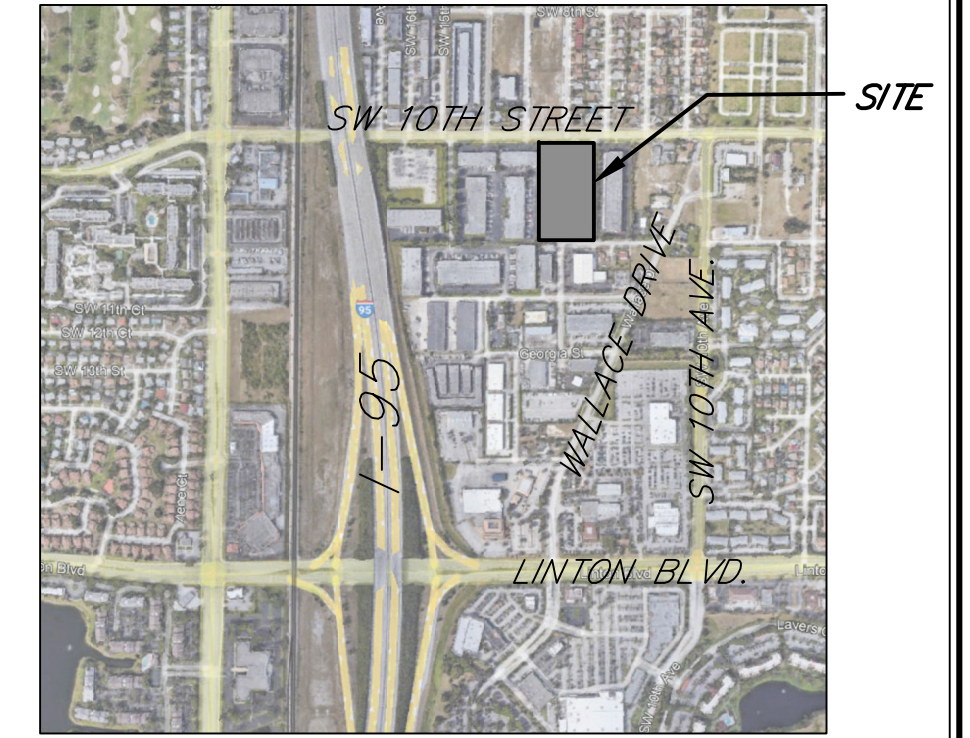


A photograph of a two-story building with a light-colored facade and dark trim, featuring several palm trees in front. A silver sedan is parked on the street in the foreground. The building has a sign that reads "WINDWARD" and a smaller sign that says "WINDWARD" and "DURHAM".

[illegible]

FIELD & WHEELER, INC.
CIVIL ENGINEERING
LANDSCAPE ARCHITECTURE – SURVEYING
7900 GLADES ROAD – SUITE 100
BOCA RATON, FLORIDA 33434
PHONE (561)–392-1991 / FAX (561)–750-1452

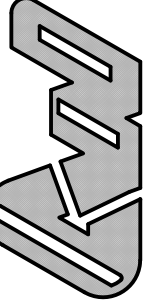

All County Paving

FLORIDA

DELRAY BEACH

DATE	04/04/24
DRAWN BY	GAH
SB./ PG.	--
SCALE	NTS



OB # 10722
HT.NO.
COV-1
OF - SHEETS

PROJECT DATA	REQ. / PERMITTED	EXISTING/ PROPOSED
FRONT SETBACK	30'	30.8' + 33'
SIDE INTERIOR SETBACK	10'	150' + 101'
SIDE STREET SETBACK	30'	--
REAR SETBACK	10'	146' + 149'
# OF STORIES		OFFICE 2, WAREHOUSE 1
LOT WIDTH	100' MIN.	351.95'
LOT DEPTH	300' MIN.	593.63'
FRONTAGE	100' MIN.	351.95'
TOTAL SITE AREA	20,000 SQ.FT. MIN.	212,602.95 SQ.FT.
PERVIOUS / IMPERVIOUS AREA		PERVIOUS 61,650 SQ.FT. IMPERVIOUS 150,952 SQ.FT.
OPEN SPACE (LANDSCAPE)		50,970 SQ.FT.
WATER BODIES	--	--
GROUND FLOOR AREA		40,702 SQ.FT.
GROSS FLOOR AREA		43,974 SQ.FT.
LOT COVERAGE	50% MAX.	20%
FLOOR AREA RATIO		.2068
DWELLING UNITS	N/A	--
DENSITY	N/A	--

1180 SW 10 Street - FILE NOS.: 24-173, 174, 175, & 176



Future Land Use: Industrial
Zoning: Industrial
Flood Zone: X
Use 4800 - Warehouse/ Distribution Terminal

211,954.36 SQ.FT.
4.865 Acres

1180 SW 10th Street
Delray Beach, FL 33444
Phone: (561) 588-0949
PCN 12-43-46-20-01-021-0032 West
PCN 12-43-46-20-01-021-0040 East


PARKING DATA	REQ. / PERMITTED	PROVIDED
PARKING OFFICE		
1ST FLOOR		
3,851 WORK + 996 CIRCULATION = 4,847 SQ.FT. GROSS	4 PER 1000, first 3000 = 12	
2ND FLOOR	3.5 PER 1000, over 3000 = 16	
7,404 SQ.FT. NET	28	25 + 3 HC
PARKING WAREHOUSE		
16,782 SQ.FT. WORK AREA	3 PER 1000 = 51	
19,586 SQ.FT. STORAGE	1 PER 1000 = 20	71
PARKING BIKE		
TYPE I	2	3
TYPE II	3	9
TOTAL PARKING	99	99

AREA TABULATIONS	SQ.FT.	%
BUILDING	41,515	19.5
ASPHALT PARKING	111,048	52.2
GRAVEL	8,299	3.8
LANDSCAPE BUFFERS	14,415	6.8
FOUNDATION PLANTING	4,156	2
INTERIOR OPEN SPACE	33,199	15.7
TOTAL SITE	212,602.95	100

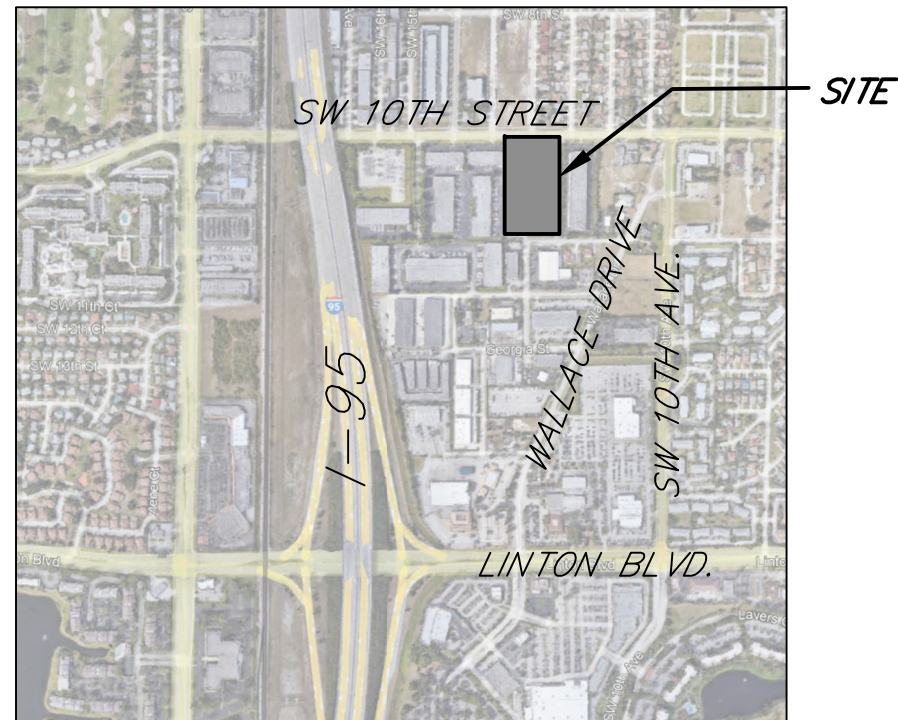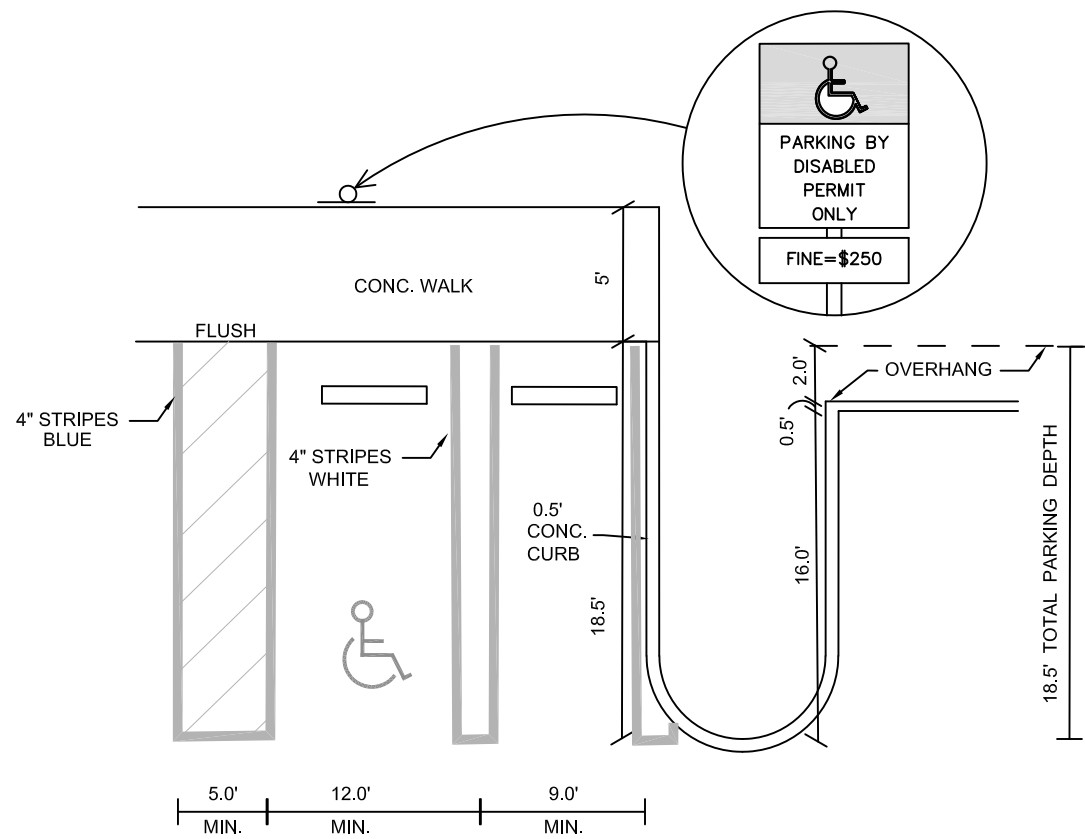

Typical Parking Layout

LOCATION MAP
(NOT TO SCALE)

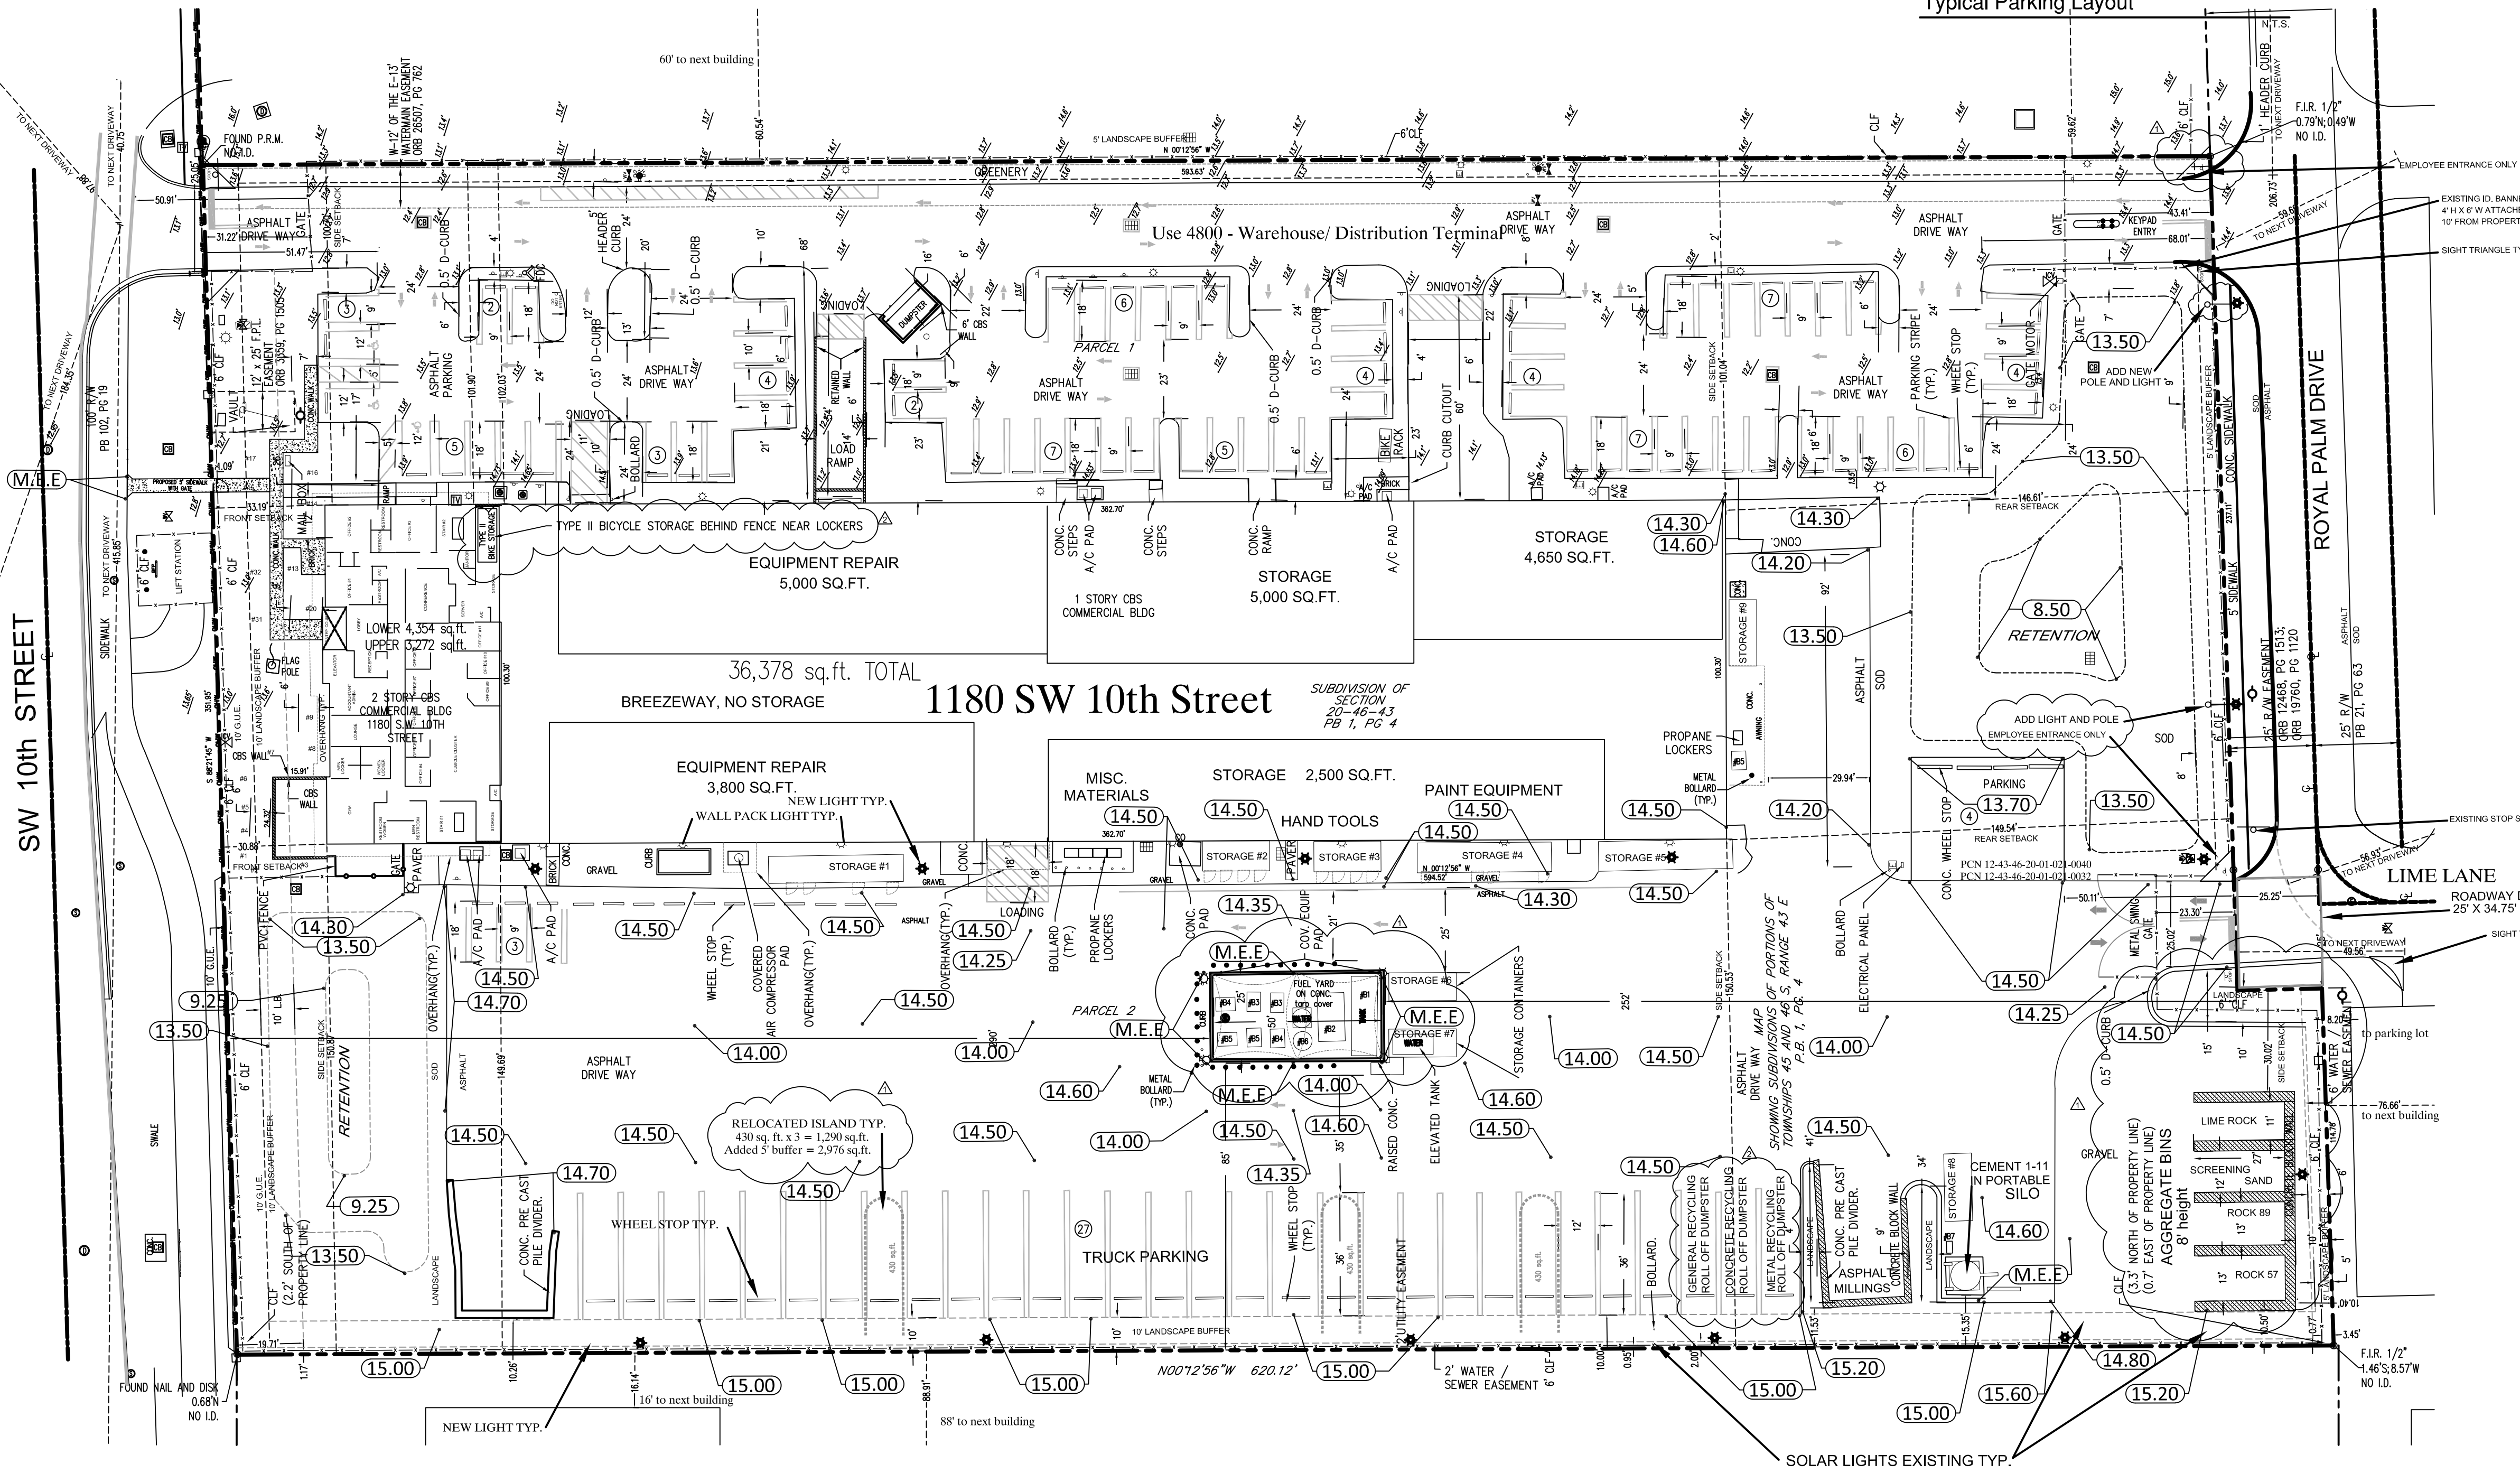


STORAGE DATA

CONTAINER DATA USE AND MANIFEST

- 480" x 102" Tare Weight= 8150 lb - 140 MPH Wind Rated USE: Shop Locker
MANIFEST: Equipment Tires, Wheels, Trucks, Large Parts
- 240" x 102" Tare Weight= 5000 lb - 150 MPH Wind Rated USE: Crew & Equipment Lockers
- Patching Crews
MANIFEST: Concrete Saws, Street Saws, Plate Tamps, Hand Tools
- 240" x 102" Tare Weight= 5000 lb - 150 MPH Wind Rated USE: Facilities Lockers
MANIFEST: Lawn Equipment, Signage and materials storage
- 480" x 102" Tare Weight= 8150 lb - 140 MPH Wind Rated USE: Trucking Locker- Uniform Locker
MANIFEST: Chains, Tumbuckles, Tie Downs, Uniforms
- 480" x 102" Tare Weight= 8150 lb - 140 MPH Wind Rated
USE: Crew & Equipment Lockers/ Seal-coat and Paving Crews
MANIFEST: Blowers, Plate Tamps, Street Saws
- 240" x 102" Tare Weight= 5000 lb - 150 MPH Wind Rated USE: Equipment Lockers - MOT
MANIFEST: Cones, Barricades
- 240" x 102" Tare Weight= 5000 lb - 150 MPH Wind Rated USE: Equipment & Material Lockers
MANIFEST: Hoses, Spray Wands, Cold Patch, Seal-coat Additives
- 240" x 102" Tare Weight= 5000 lb - 150 MPH Wind Rated
USE: Equipment Locker - Concrete Crews
MANIFEST: Concrete Saws, Jack Hammers, Hand Tools and Forms
- 240" x 102" Tare Weight= 5000 lb - 150 MPH Wind Rated
USE: Equipment Locker - Striping Crews
MANIFEST: Miscellaneous Equipment and hand tools

STORAGE TANK DATA
B1. TARCONTE SEALER - 4500 GAL DOUBLE WALL STEEL - 21'5" L x 8' W x 8' H - STATIONARY
B2. POLYTARPO SEALER - 4500 GAL DOUBLE WALL STEEL - 13' L x 11' W x 11' H - STATIONARY
B3. HIGH SULFUR DIESEL - 500 GAL DOUBLE WALL STEEL - 6'5" L x 4' W x 4' H - STATIONARY
B4. OFF ROAD DIESEL - 500 GAL DOUBLE WALL STEEL - 6'5" L x 4' W x 4' H - STATIONARY
B5. GASOLINE - 500 GAL DOUBLE WALL STEEL STEEL - 6'5" L x 4' W x 4' H - STATIONARY
B6. DIESEL EXHAUST FLUID - 55 GAL HDPE - STATIONARY
B7. DARCOLE CONCRETE AGENT - 55 GAL HDPE - PORTABLE TOTE (next to silo)
SEE CUT SHEETS FOR ADDITIONAL DETAILS

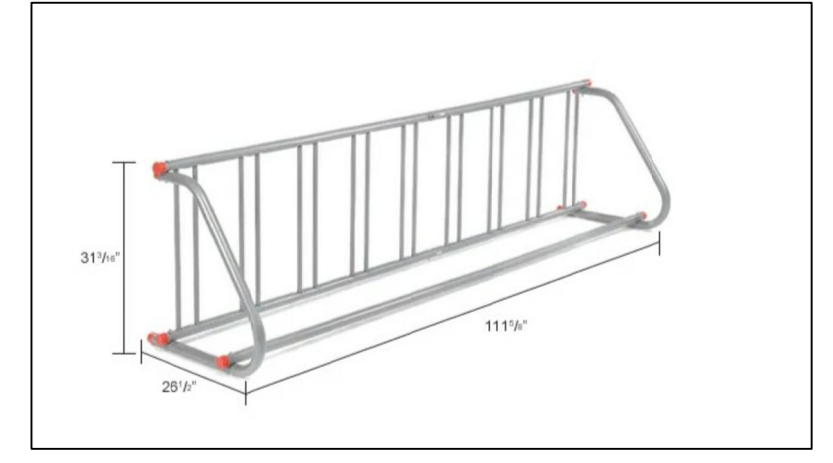


OUTDOOR BIKE RACK, 9 BIKE CAPACITY
TYPE 2 BICYCLE STORAGE BEHIND FENCED CAGE

LEGAL DESCRIPTION:

Parcel 1:
The East 211.11 feet of Lot 21, Section 20, Township 46 South, Range 43 East, of Map Showing Subdivisions of Portions of Townships 45 and 46 South, Range 43 East, Palm Beach County, Florida; Less the North 50 feet thereof for right-of-way of Southwest 10th street, according to the map or plat thereof as recorded in Plat Book I, Page 4, Public Records of Palm Beach County, Florida.

Parcel 2:
The West 140.74 feet of the East 351.85 feet of Lot 21, Section 2 O, Township 46 South, Range 43 East, of Map Showing Subdivisions of Portions of Townships 45 and 46 South, Range 43 East, Palm Beach County, Florida; Less the North 50 feet thereof for right-of-way of Southwest 10th street, according to the map or plat thereof as recorded in Plat Book 1, Page 4, Public Records of Palm Beach County, Florida.

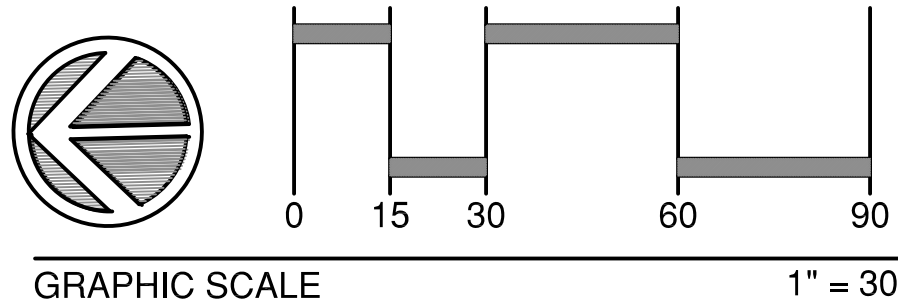

REVISOR	DATE	BY
04/24/25	JEM	
02/27/25	GAH	
11/19/24	GAH	
REVISIONS	DATE	BY
FILE NAME	99920-AND	






CAULFIELD & WHEELER, INC.
CIVIL ENGINEERING
LANDSCAPE ARCHITECTURE - SURVEYING
7900 GLADES ROAD - SUITE 100
BOCA RATON, FLORIDA 33434
PHONE (561) 392-1991 / FAX (561) 750-1452

All County Paving
SITE PLAN
FLORIDA
DELRAY BEACH

DATE	04/04/24
DRAWN BY	GAH
F.B. / PG.	--
SCALE	1"=30'

G. ALLAN HENDRICKS
LANDSCAPE ARCHITECT
No. LA6669974
STATE OF FLORIDA
FOR THE FIRM

JOB # 10722
SHT. NO.
SP-1
OF 2 SHEETS

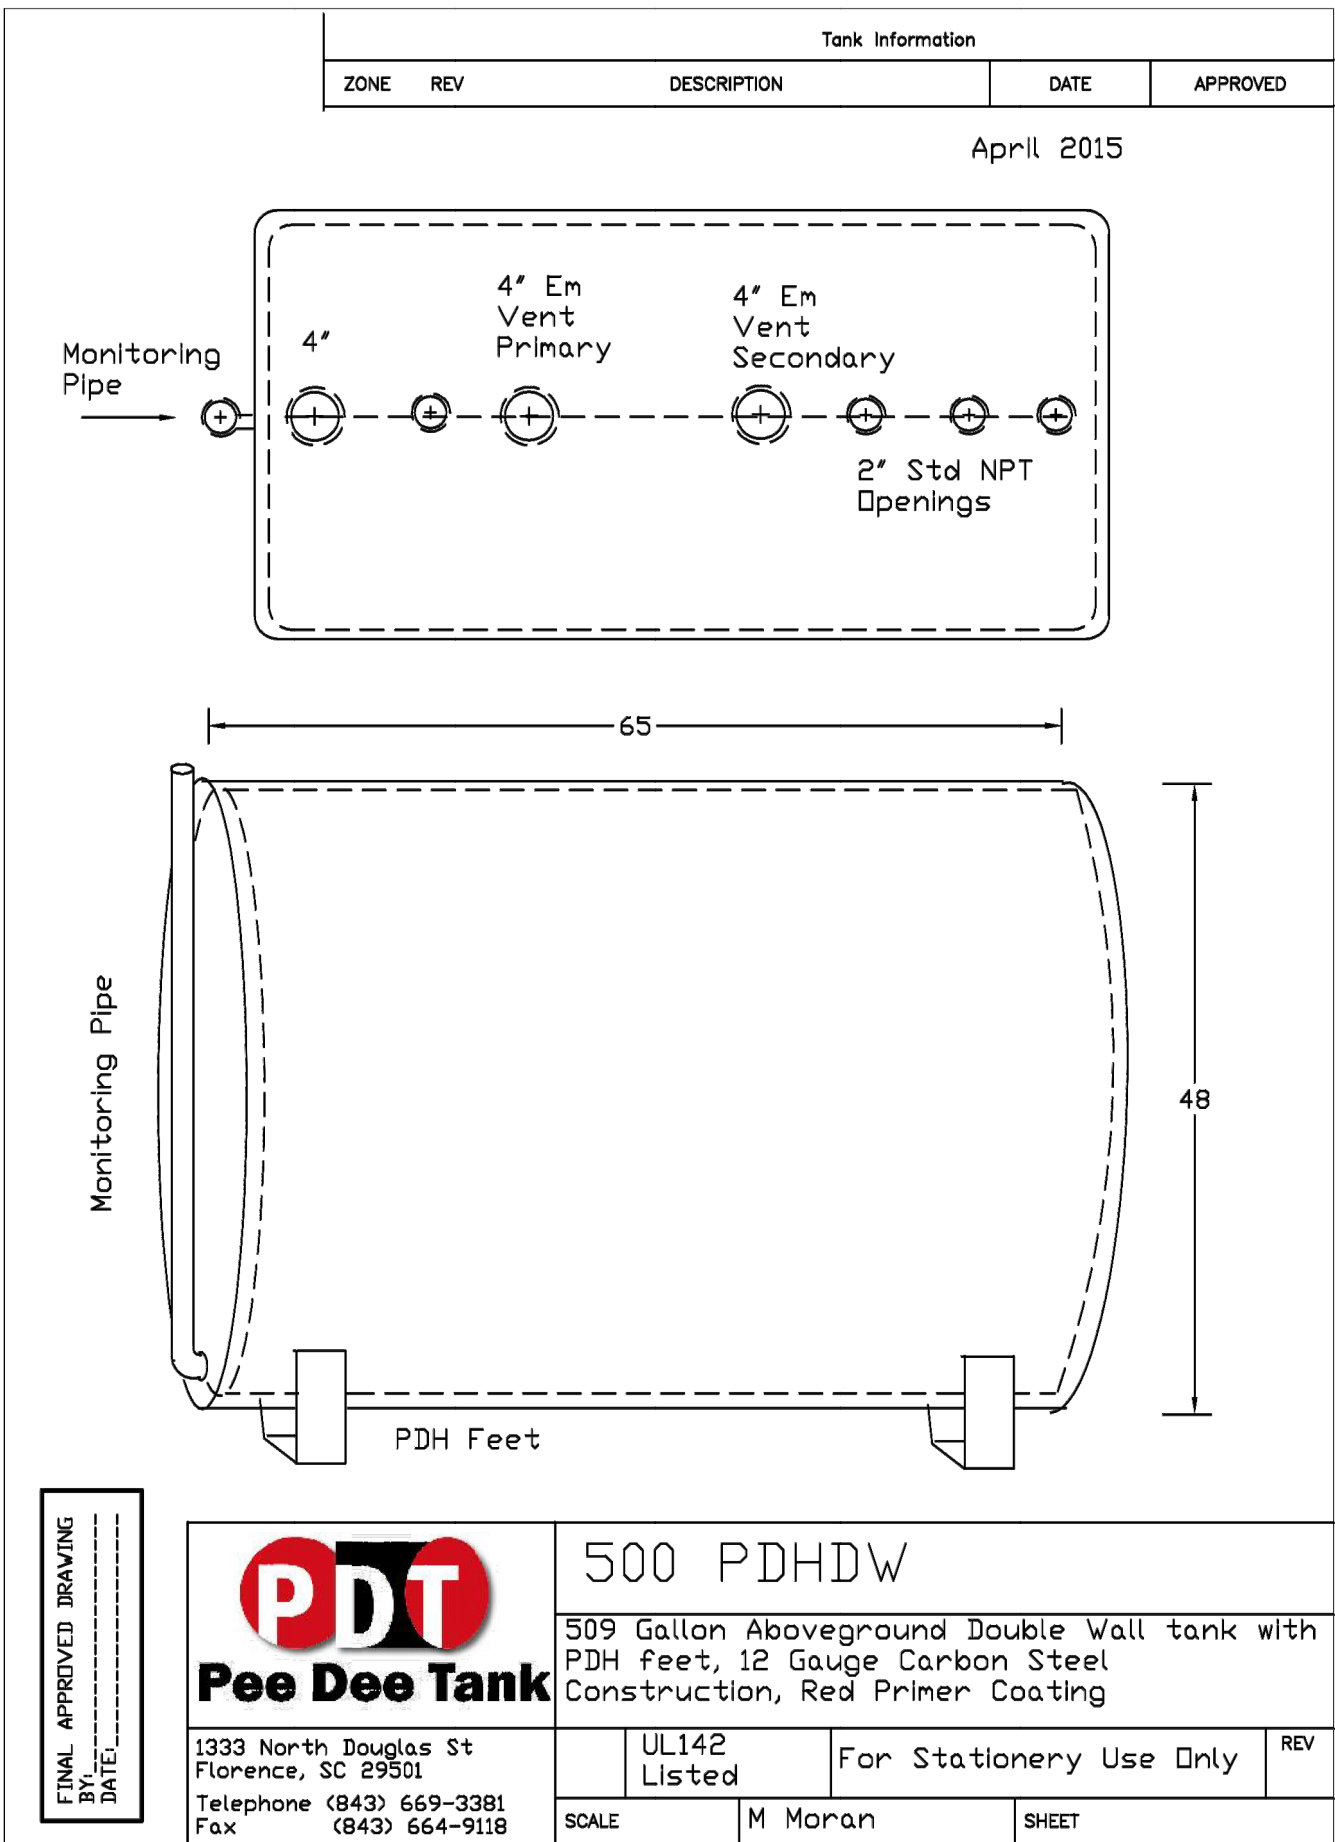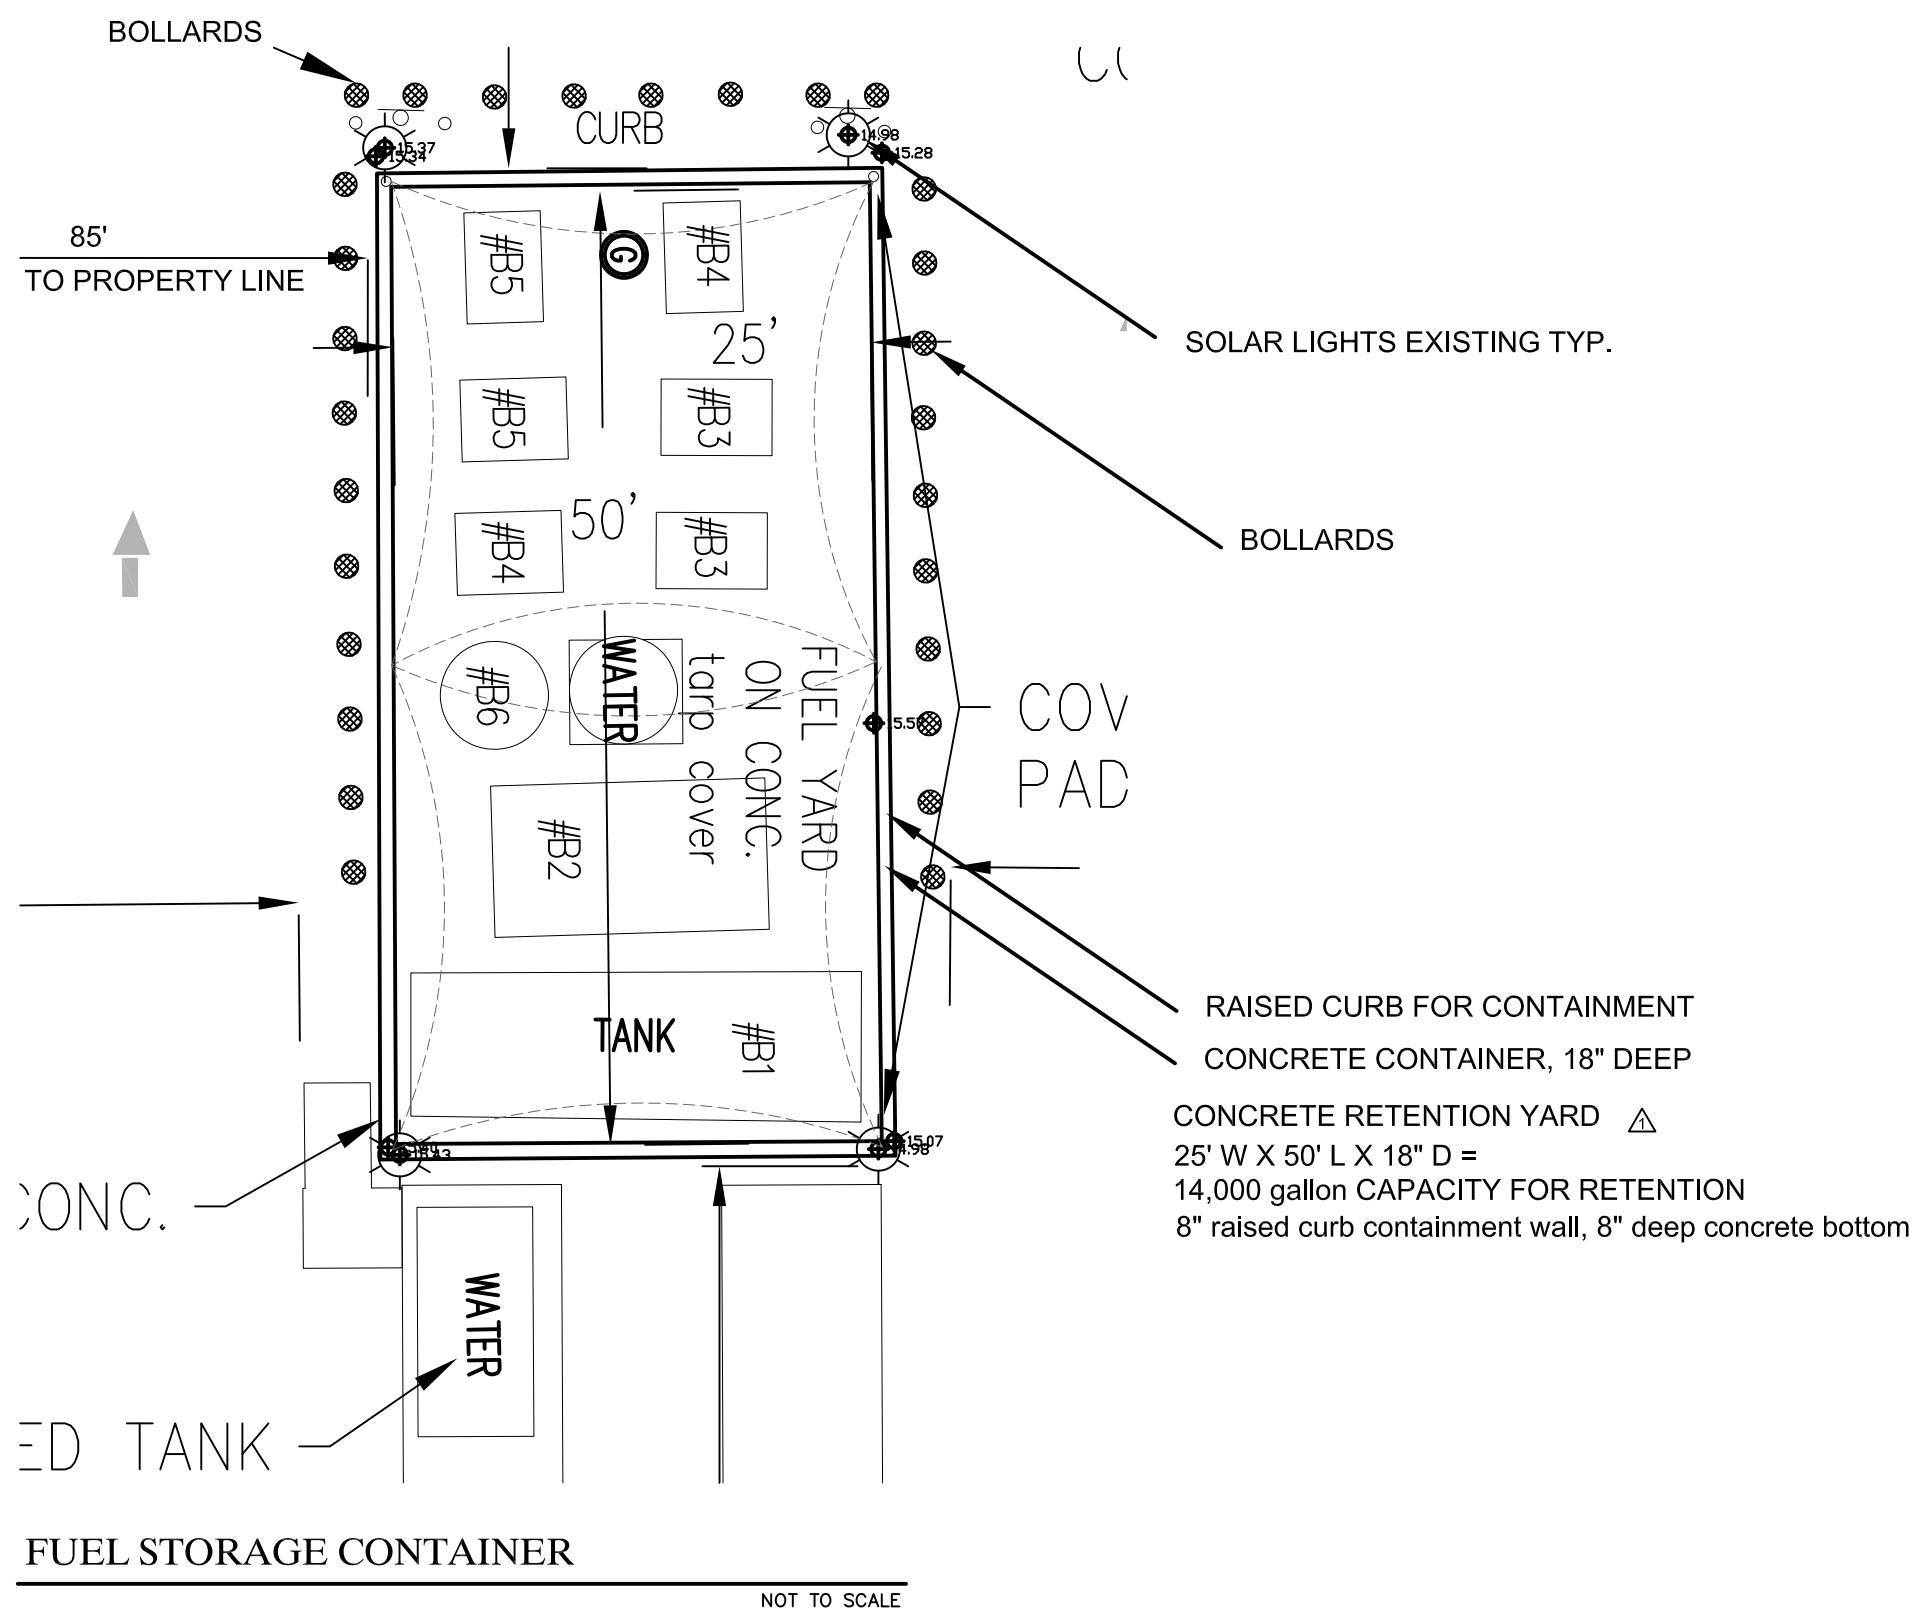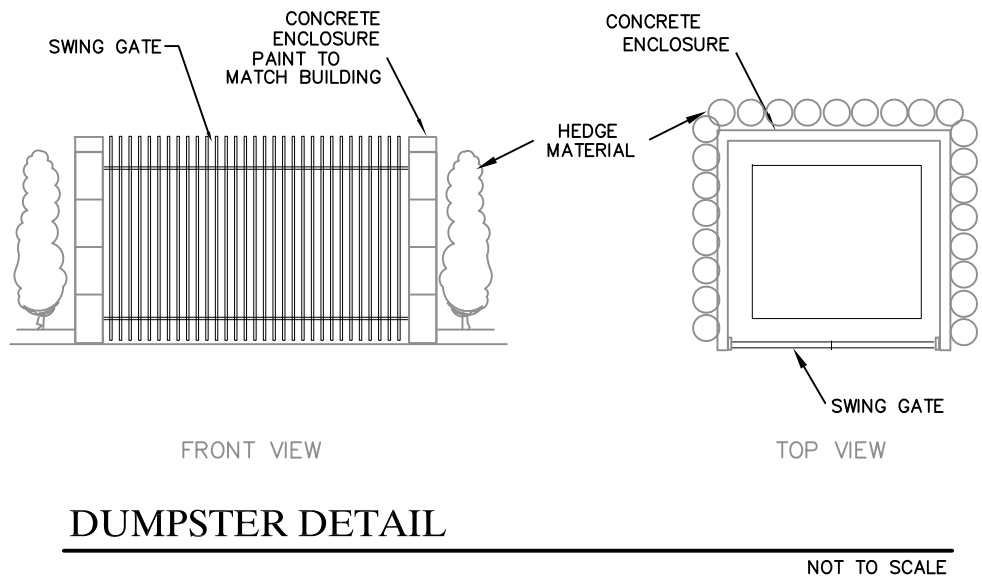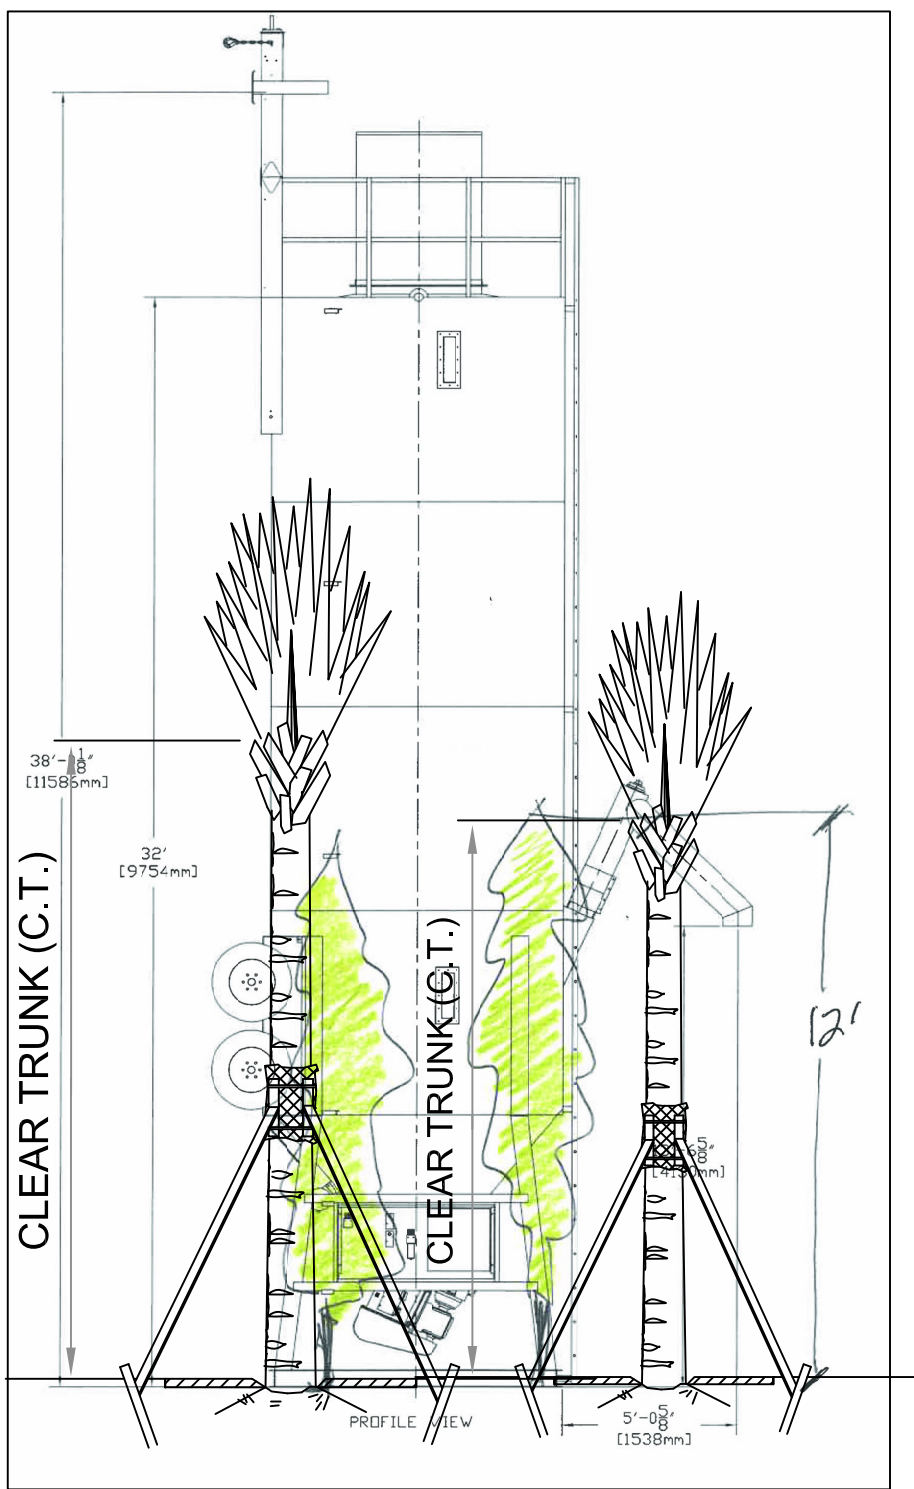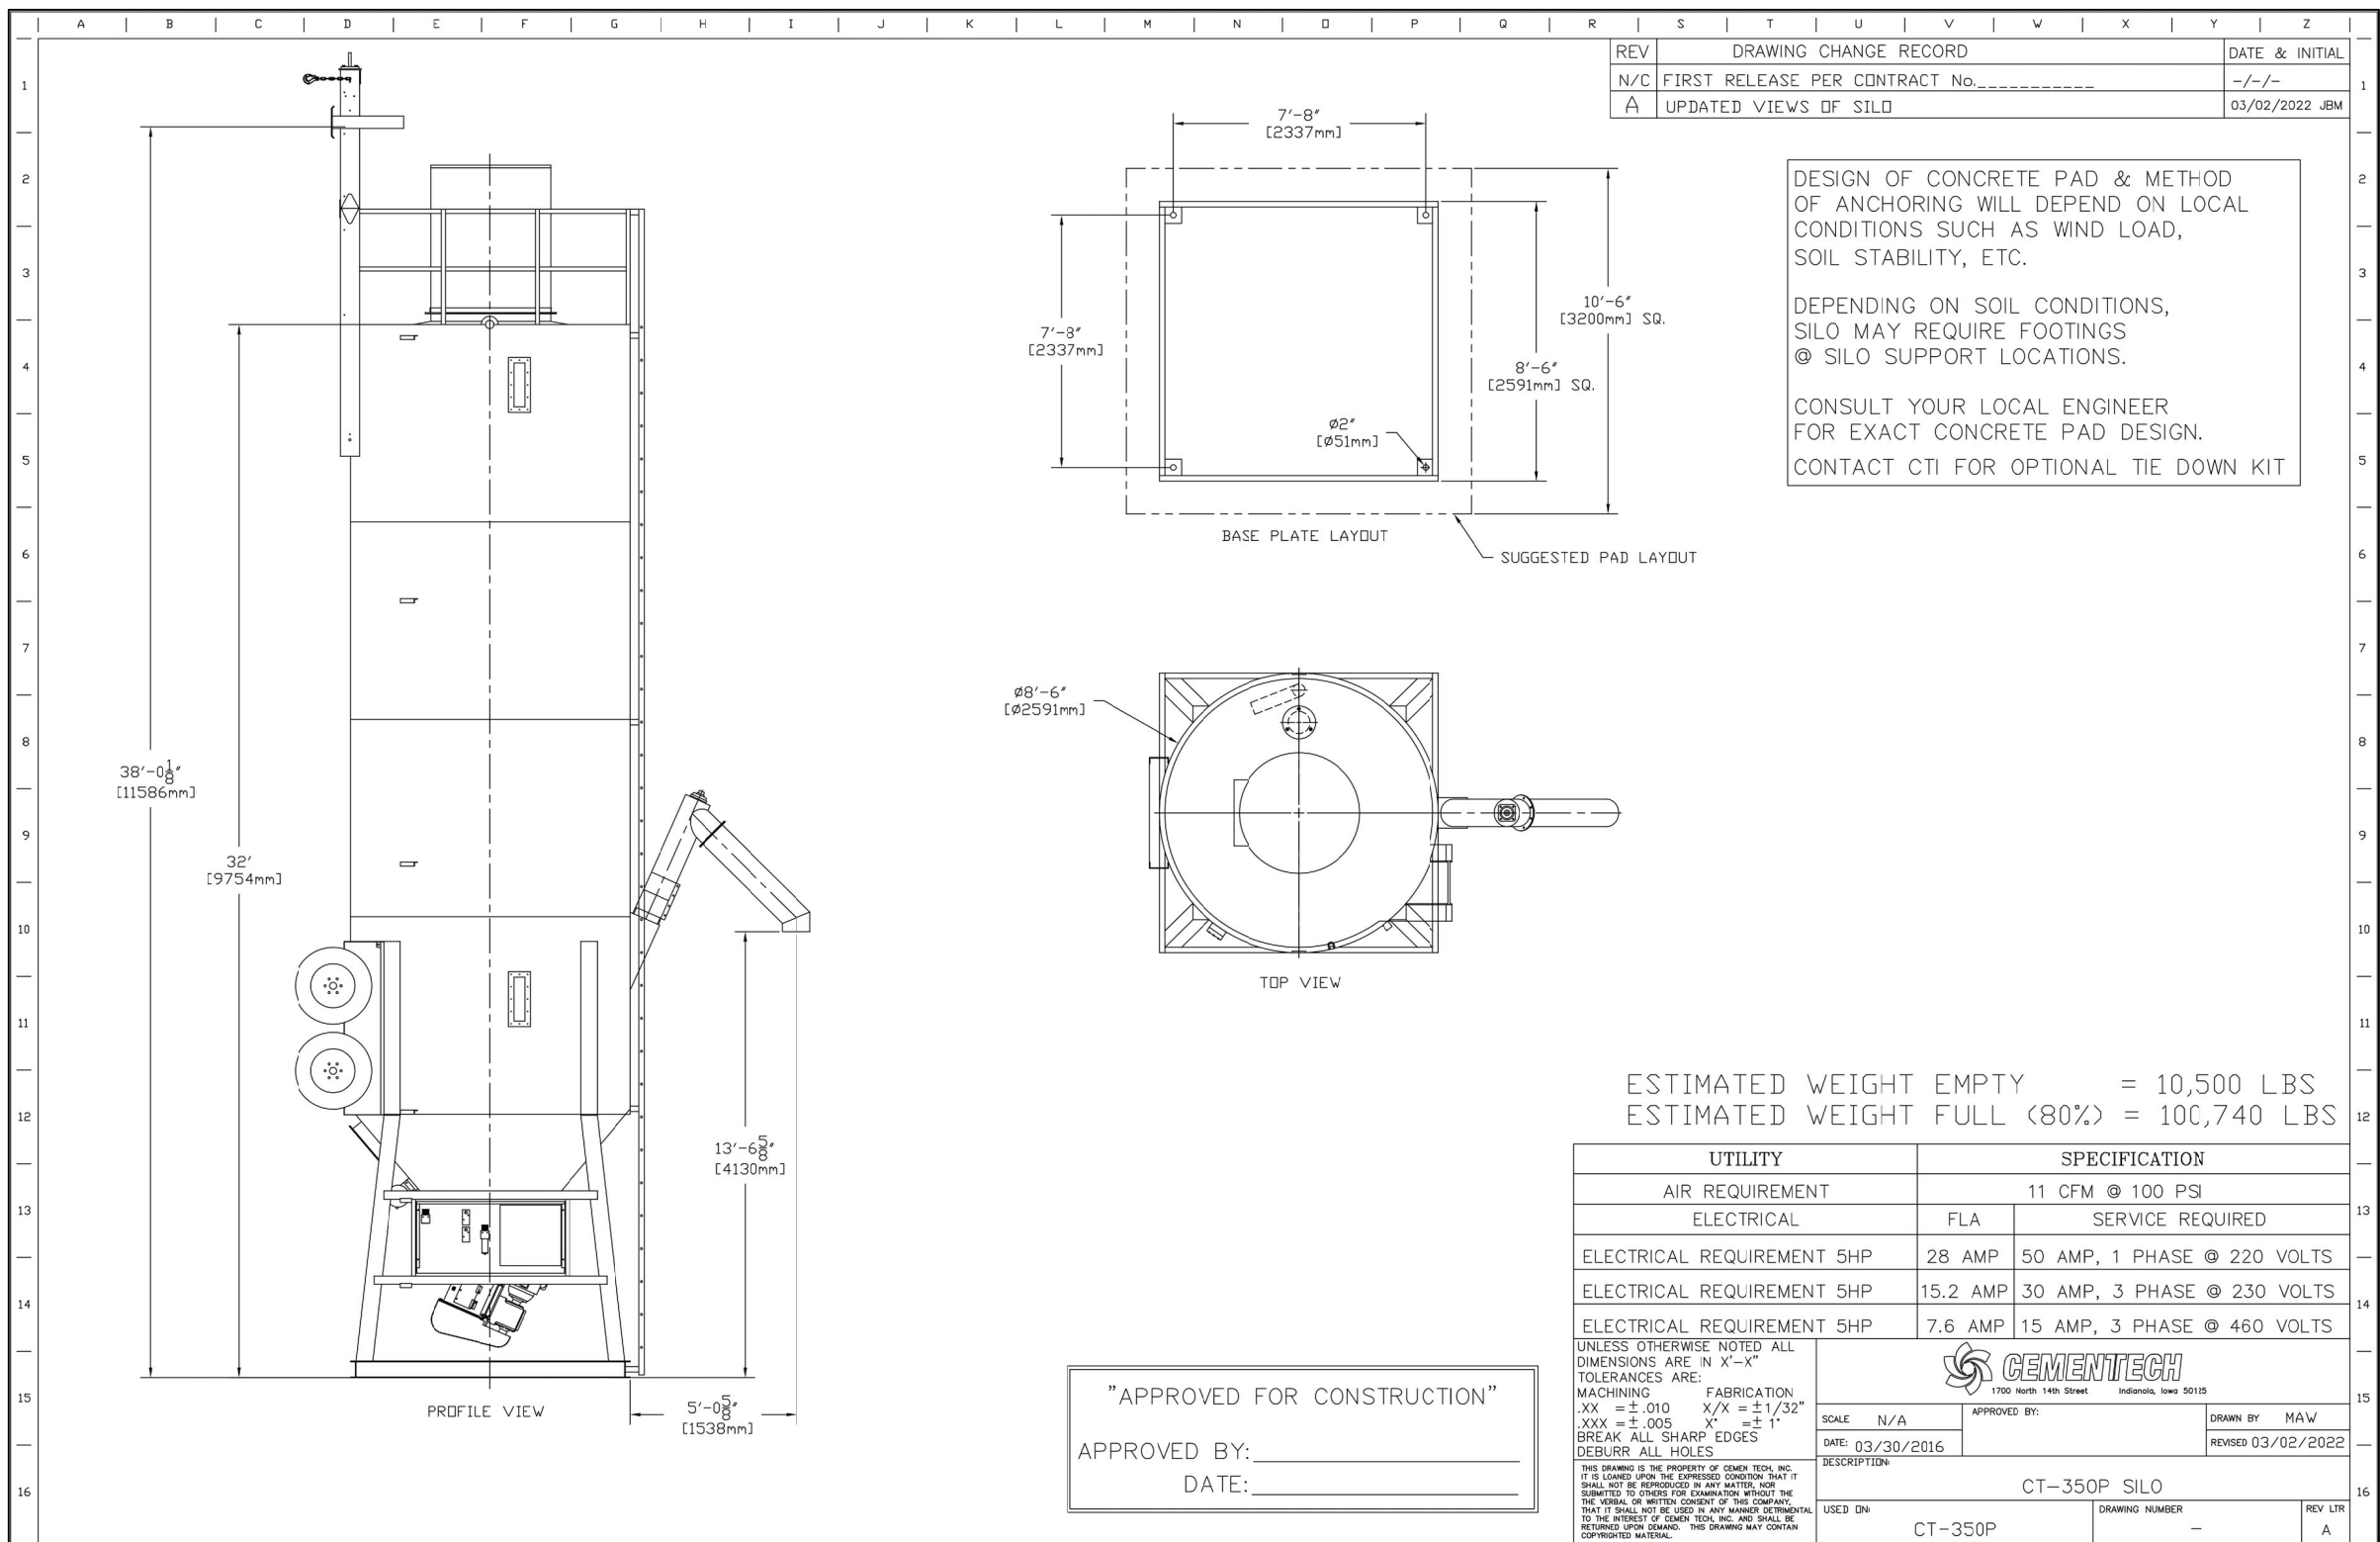

DR-6000 Skid Bulk Tank

ASPHALT SEALCOATING EQUIPMENT

Sales 770-832-1192
Part & Service 770-646-6998

www.ditchrunner.net

Reid Manufacturing LLC.
155 Evelyn S. Wade Blvd.
Buchanan, GA. 30113

Standard features:

- 550 to 10,000 Gallon Material Capacity
- Heavy gauge materials for high durability
- Easy operator control panel for mixing and pump control
- Bowie™ gear pump for reliable material transfers
- 3 blade offset agitation for material mixing
- Large material inspection plate for easy access and cleaning.
- Twin Cylinder 16HP Gas Briggs™ Engines or 230/460 3 Phase AC power
- 2-15/16" Solid Shaft

REV	DATE	INITIAL
N/C FIRST RELEASE PER CONTRACT No.		
A UPDATED VIEWS OF SILO	01/02/2022	JM

CAULFIELD & WHEELER, INC.
CIVIL ENGINEERING
LANDSCAPE ARCHITECTURE - SURVEYING
7900 GLADES ROAD - SUITE 100
BOCA RATON, FLORIDA 33434
PHONE (561) 392-1991 / FAX (561) 750-1452






All County Paving
SITE PLAN DETAILS
DELRAY BEACH
FLORIDA

DATE	04/04/24
DRAWN BY	GAH
F.B./ PG.	--
SCALE	1"=30'

G. ALLAN HENDRICKS
LANDSCAPE ARCHITECT
No. LA6666974
STATE OF FLORIDA
FOR THE FIRM



JOB # 10722
SHT. NO.
SP-2
OF 2 SHEETS

JOB # 10722
SHT. NO.
LP-1
OF 2 SHEETS

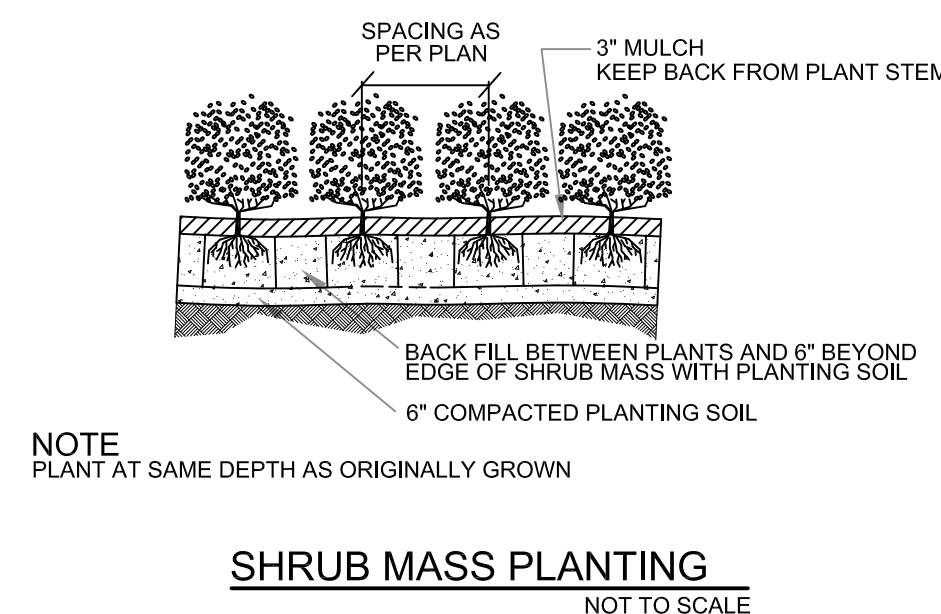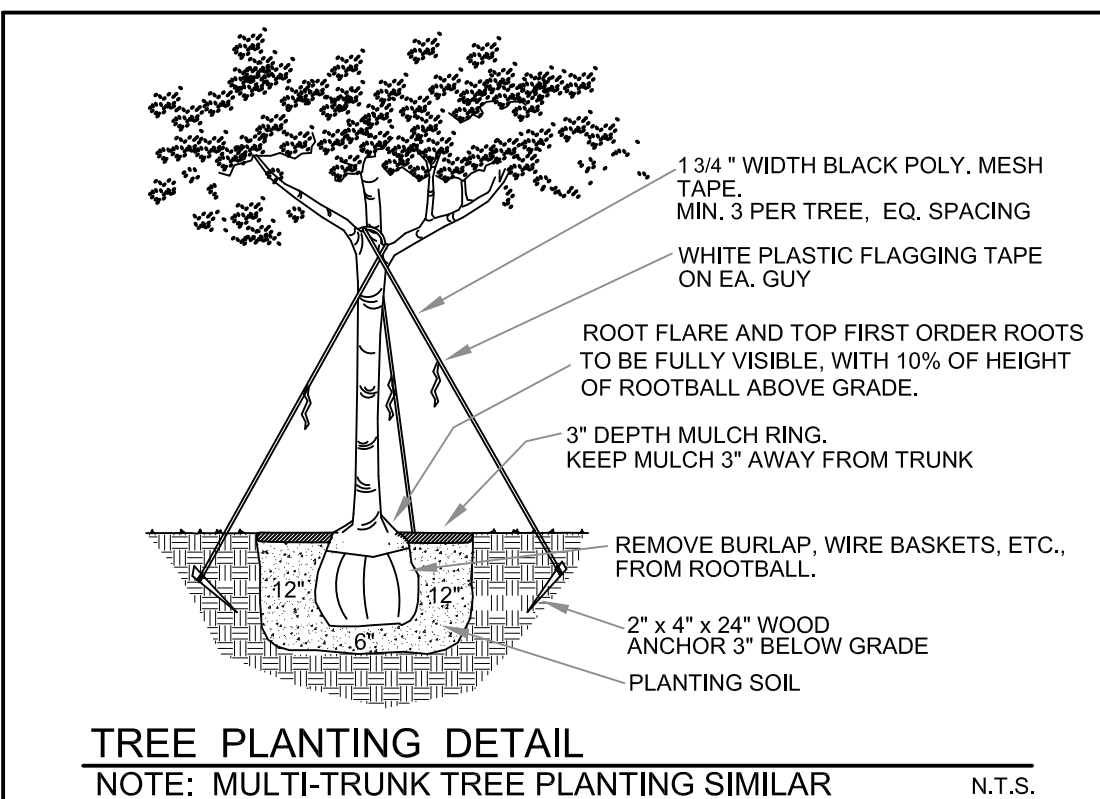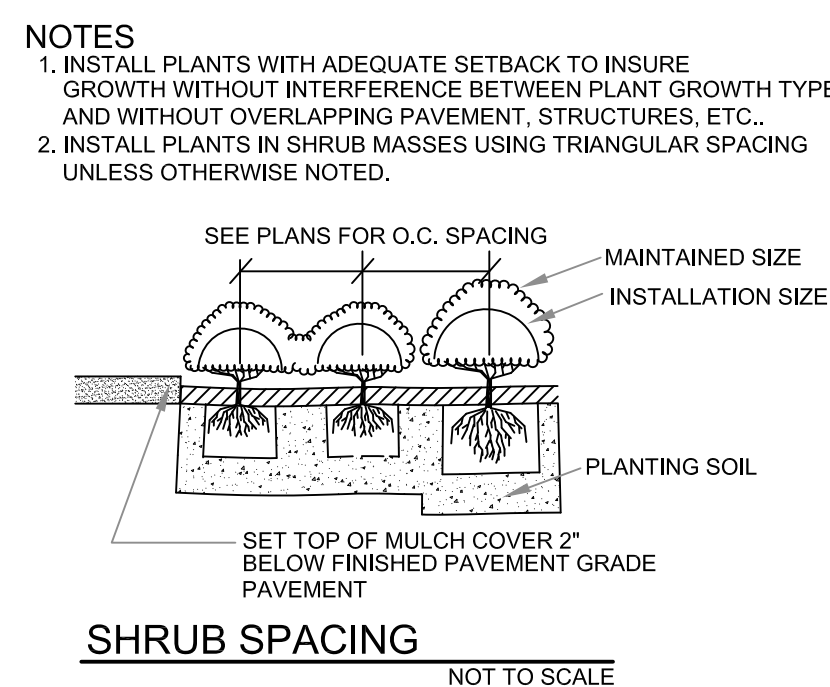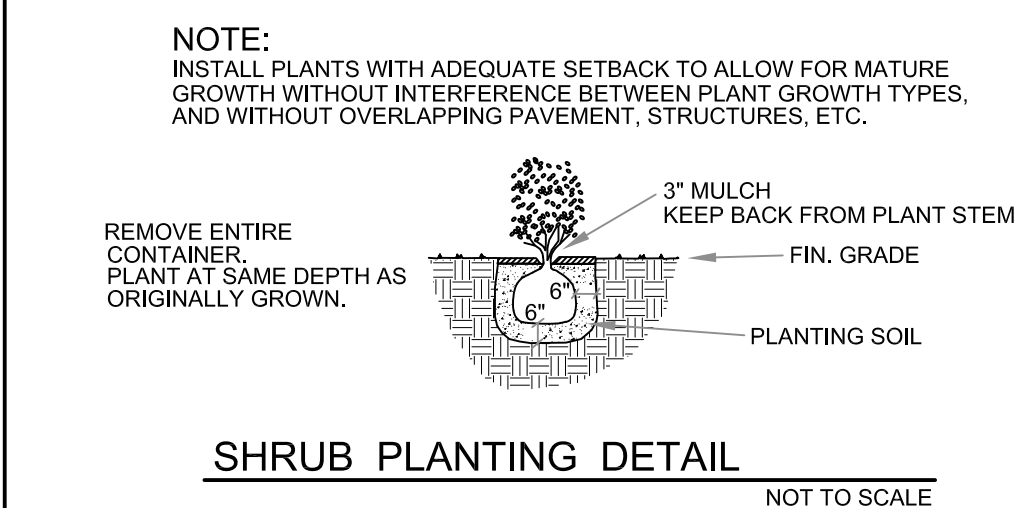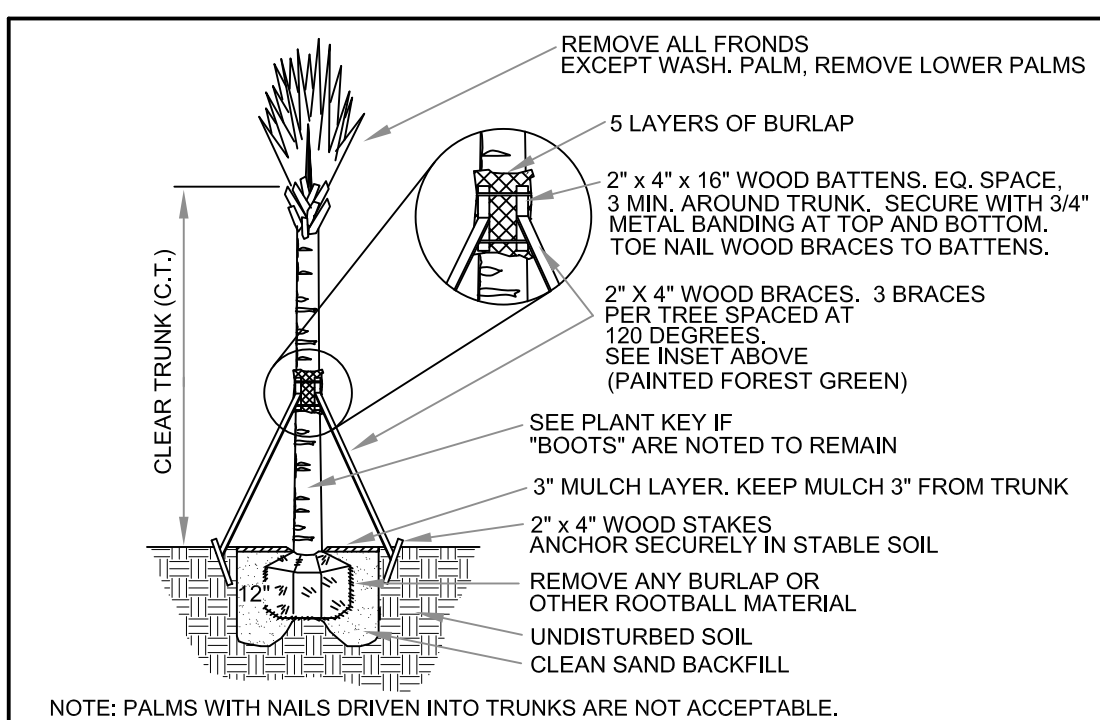

LANDSCAPE NOTES

1. ALL LANDSCAPE AND SPECIFICATIONS SHALL MEET OR EXCEED THE MINIMUM REQUIREMENTS AS PROVIDED BY CITY OF DELRAY BEACH LAND DEVELOPMENT REGULATIONS.
2. ALL PLANTING MATERIAL SHALL MEET OR EXCEED FLORIDA GRADE #1 AS SPECIFIED IN GRADES AND STANDARDS FOR NURSERY PLANTS, CURRENT EDITION.
3. ALL SIZES SHOWN FOR PLANT MATERIAL ON THE PLAN ARE TO BE CONSIDERED AS MINIMUMS. ALL PLANT MATERIAL MUST MEET OR EXCEED THESE MINIMUM REQUIREMENTS FOR BOTH HEIGHT AND SPREAD. ANY OTHER REQUIREMENTS FOR SPECIFIC SHAPE OR EFFECT AS NOTED ON THE PLAN WILL ALSO BE REQUIRED FOR ACCEPTANCE.
4. LANDSCAPE SHALL BE PLACED TO EDGE OF ABUTTING STREETS, CANALS, LAKES OR OTHER LANDS.
5. ALL MECHANICAL EQUIPMENT, AIR CONDITIONING, IRRIGATION PUMP STATIONS AND EQUIPMENT, FPL TRANSFORMERS, POOL PUMPS, ETC. MUST BE SCREENED ON THREE (3) SIDES BY LANDSCAPE SHRUBS.
NOTE: THE QUANTITY OF SCREENING SHRUBS MAY BE IN ADDITION TO THE REQUIRED NUMBER OF SHRUBS AS PROVIDED IN THE CODE CALCULATION TABLE. ALL SCREENING SHRUBS SHALL BE PLANTED FOR PROPER OPERATION OF EQUIPMENT BEING SCREENED AND/OR PER THE REQUIREMENTS OF THE UTILITY AS NECESSARY.
6. GUYING/STAKING PRACTICES SHALL NOT PERMIT NAILS, SCREWS, WIRES, ETC. TO PENETRATE OUTER SURFACES OF TREES, PALMS OR OTHER PLANTED MATERIAL. TREES, PALMS AND PLANT MATERIAL WILL BE REJECTED DUE TO THIS PRACTICE.
7. BURLAP MATERIAL, WIRE CAGES, PLASTIC/CANVAS STRAPS, ETC. MUST BE CUT AND REMOVED FOR THE TOP ONE-HALF (1/2) DEPTH OF THE ROOT BALL. TREES AND SHRUBS GROWN IN GROW BAGS OR GROW BAG TYPE MATERIAL MUST HAVE SUCH MATERIAL REMOVED ENTIRELY PRIOR TO PLANTING THE TREE OR SHRUB.
8. ALL PLANT MATERIAL SHALL BE FREE OF PESTS, INSECTS, DISEASE, WEEDS, ETC.
9. ALL PLANT MATERIAL SHALL BE PLANTED AT THE PROPER DEPTHS, AS ORIGINALLY GROWN AND/OR SO THE TOP OF THE ROOT BALL IS FLUSH OR SLIGHTLY ABOVE FINISHED GRADE IMMEDIATELY AFTER PLANTING. ALL TREES SHOULD PROVIDE TRUNK TAPER WHEN PROPERLY PLANTED AT THE CORRECT PLANTING DEPTH.
10. ALL PLANT MATERIAL SHALL BE WATERED IN AT TIME OF PLANTING TO ELIMINATE AIR POCKETS IN THE ROOT ZONE AREA.
11. UPON COMPLETION OF WORK, THE SITE SHALL BE CLEARED OF ALL DEBRIS, SUPERFLUOUS MATERIALS, AND EQUIPMENT CAUSED BY THIS PERMIT.
12. ALL LANDSCAPED AREAS SHALL BE PROVIDED WITH AN UNDERGROUND FULLY AUTOMATIC IRRIGATION SYSTEM USING POP-UP SPRINKLERS. SYSTEM SHALL PROVIDE 100% COVERAGE WITH A 50% OVERLAP (MINIMUM) USING RUST-FREE WATER, EXCEPT ANY PRESERVED AREAS REMAINING IN NATURAL STATE. A RAIN SENSOR DEVICE OR SWITCH SHALL BE INSTALLED THAT WILL OVERRIDE THE IRRIGATION SYSTEM WHEN ADEQUATE RAINFALL HAS OCCURRED. WATER SHALL NOT BE DIRECTED AND/OR PROVIDED ONTO IMPERVIOUS SURFACES AND/OR BE DESIGNED OR INSTALLED TO THROW WATER OVER AN IMPERVIOUS SURFACE SUCH AS A SIDEWALK, ETC. HOURS OF OPERATION FOR ALL IRRIGATION SYSTEMS SHALL BE LIMITED TO 5:00 P.M. TO 8:00 A.M. ONLY OR AS MAY BE FURTHER RESTRICTED BY SOUTH FLORIDA WATER MANAGEMENT DISTRICT OR OTHER JURISDICTIONAL AGENCY.
13. ALL PLANT MATERIAL AND WORK SHALL BE GUARANTEED FOR ONE-YEAR FROM FULLY EXECUTED SUBSTANTIAL COMPLETION CERTIFICATE. DURING THE ONE YEAR GUARANTEE, ANY PLANT MATERIAL THAT DIES OR IS IN AN UNHEALTHY CONDITION SHALL BE REPLACED WITH THE SAME PLANT TYPE AT LEAST EQUAL TO THE SIZE AND QUALITY ORIGINALLY SPECIFIED. THE REPLACEMENT MATERIAL SHALL ALSO BE GUARANTEED FOR ONE YEAR FROM THE DATE OF ITS INSTALLATION. THE GUARANTEE WILL BE NULL AND VOID IF PLANT MATERIAL IS DAMAGED OR KILLED BY LIGHTNING, HURRICANE FORCE WINDS, HAIL OR FREEZE.
14. THE LANDSCAPE CONTRACTOR IS RESPONSIBLE FOR VERIFYING THERE ARE NOT CONFLICTS WITH ABOVE OR BELOW GROUND UTILITIES PRIOR TO COMMENCING LANDSCAPE INSTALLATION. NOTIFY OWNER IF CONFLICTS EXIST.
15. ANY TREES TO REMAIN SHALL BE PRUNED IN SUCH A WAY TO PROMOTE PROPER HORTICULTURAL AND NATURAL TREE GROWTH.
16. ALL TREES AND PALMS SHALL BE PLACED A MINIMUM OF 5' FROM UNDERGROUND UTILITIES.
17. GROUND COVERS SHALL BE SPACED AS NOTED OR TO INSURE GROUND COVER WITHIN 6 MONTHS OF PLANTING.
18. ALL EXISTING PLANTING BED SOILS SHALL BE REPLACED TO A DEPTH OF 30 INCHES.
19. MULCH SHALL BE EUCALYPTUS OR MELALEUCA MULCH. ALL TREES ARE TO HAVE A 30" RING COVERED WITH A 3" LAYER OF COMPACTED MULCH. ALL SHRUB BEDS WITH A 3" LAYER OF COMPACTED MULCH.
20. ALL PLANT MATERIAL SHALL BE FERTILIZED WITH A TABLET FORM BALANCED FERTILIZER CONTAINING MINOR ELEMENTS. FOLLOW MANUFACTURER'S RECOMMENDATIONS FOR RATES. SOD AREAS SHALL BE FERTILIZED WITH A GRANULAR FORM BALANCED FERTILIZER WITH MINOR ELEMENTS FOLLOWING MANUFACTURER'S RECOMMENDATIONS FOR RATES.
21. PLANTING SOIL SHALL BE A MIX OF 1/3 NATIVE SOIL, 1/3 CLEAN SAND & 1/3 PEAT. IF NATIVE SOIL IS UNACCEPTABLE, CONTACT LANDSCAPE ARCHITECT.
22. ALL LANDSCAPING SHALL BE INSTALLED IN A WORKMANLIKE MANNER, AND ACCORDING TO ACCEPTED GOOD PLANTING PROCEDURES WITH QUALITY PLANT MATERIALS AS HEREIN DESCRIBED.
23. ALL PROHIBITED PLANT SPECIES SHALL BE REMOVED FROM THE SITE.
24. ALL LANDSCAPE AREAS TO BE TREATED WITH PRE EMERGENT WEED CONTROL PRIOR TO MULCH INSTALLATION. ADDITIONAL WEED CONTROL SHALL BE THE RESPONSIBILITY OF THE LANDSCAPE CONTRACTOR UNTIL FINAL SIGN OFF BY THE CITY OF DELRAY BEACH.

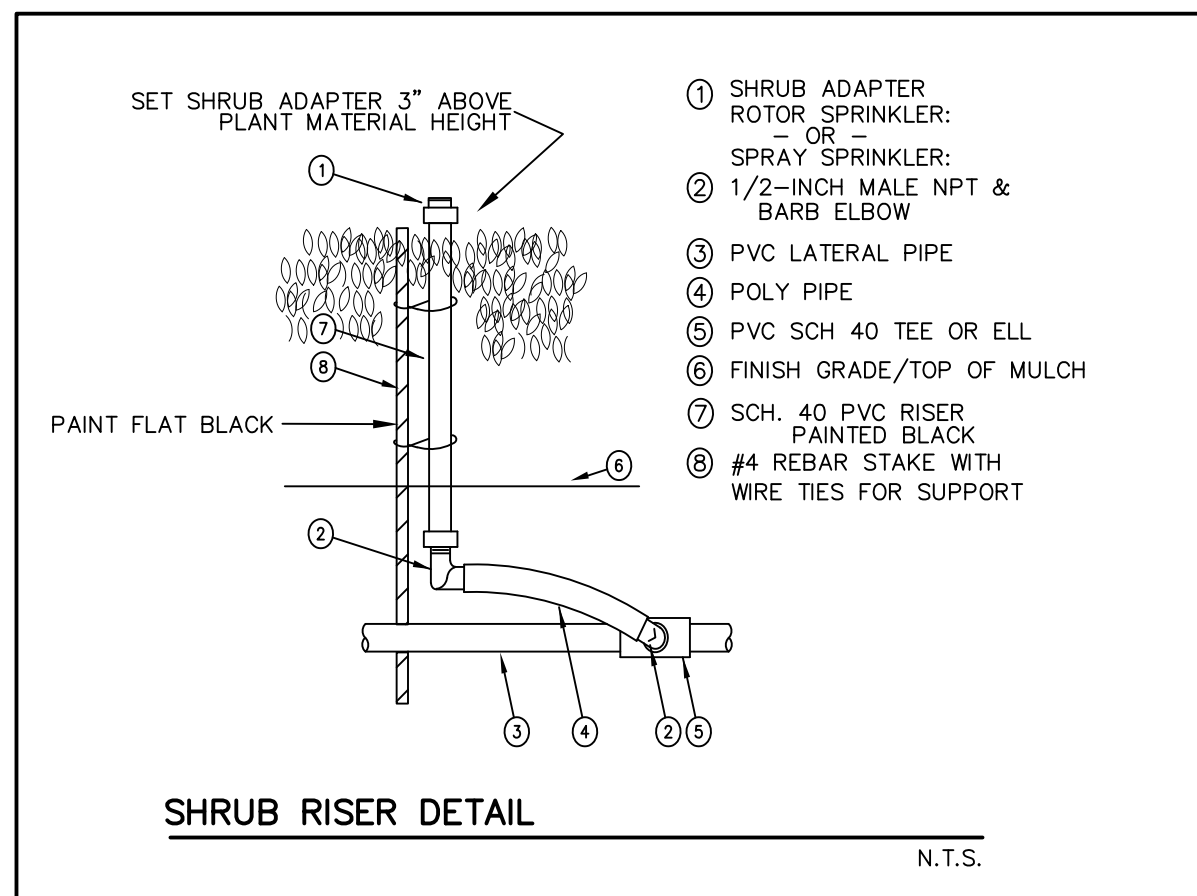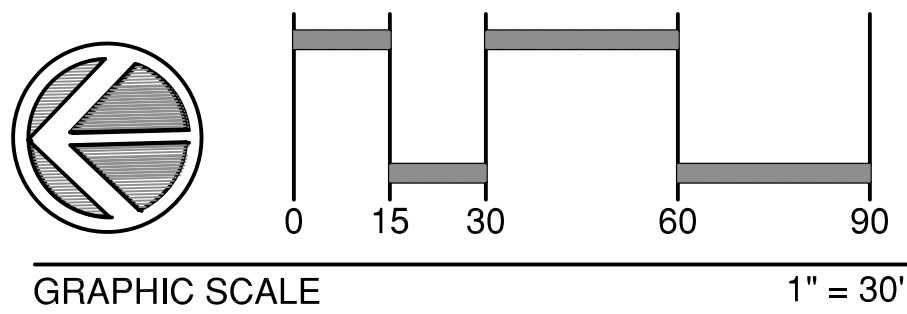

IRRIGATION KEY				
SYMBOL	ARC*	SPRAY HEAD / STANDARD TRAJECTORY*	PSI	GPM
	FULL OR PART,	RAINBIRD 15 SERIES MPR	25	0.82–3.30
	H	RAINBIRD 10 SERIES MPR	25	2.07
	H	RAINBIRD 15 SERIES END STRIP	25	0.56
	F	RAINBIRD 15 SERIES SIDE STRIP	25	1.11
	CONNECT TO EXISTING SYSTEM RAINBIRD MODEL RSD—BEX RAIN SHUT-OFF DEVICE			

- ## NOTES
1. SEE THIS SHEET DETAILS AND ADDITIONAL NOTES.
 2. VALVE LOCATIONS ARE FOR GRAPHIC PURPOSES ONLY.
 3. PULL A SPARE WIRE FROM THE FURTHEST VALVE IN EACH RUN TO THE CONTROLLER (THROUGH EACH VALVE BOX) AND CLEARLY LABEL "SPARE" IN EACH VALVE BOX AND AT CONTROLLER.
 4. THE IRRIGATION PLAN IS SCHEMATIC. IRRIGATION CONTRACTOR SHALL PROVIDE 100% COVERAGE WITH A MIN. 100% OVERLAP. HEADS SHALL BE PLACED TO MINIMIZE OVERSPRAY ON BUILDINGS AND PAVEMENT.
 5. NO ADJUSTMENT TO THE SPRAY HEADS NOTED ON THE PLAN MAY BE REQUIRED.
 6. SPRAY HEADS IN SHRUB AREAS THAT ARE ADJACENT TO WALKS SHALL BE RAINBIRD 1800 SERIES 12" POP-UPS
 7. SPRAY HEADS IN OPEN SHRUB AREAS SHALL BE ON A RISER WITH SHRUB ADAPTER AS NOTED IN THE DETAIL THIS SHEET.
 8. SPRAY HEADS IN GRASS AREAS SHALL BE RAINBIRD 1800 SERIES 6" POP-UPS.

NOTE:
CONTRACTOR SHALL ADJUST ALL HEADS AS REQUIRED TO ACCOMMODATE ANY VERTICAL OBSTRUCTIONS THAT MAY OCCUR, INCLUDING BUT NOT LIMITED TO LIGHT POLES, FIRE HYDRANTS, ETC. VERIFY ALL HEAD LAYOUT WITH OWNER'S AUTHORIZED REPRESENTATIVE PRIOR TO COMMENCING WORK.

[illegible]

CAULFIELD & WHEELER, INC.
 CIVIL ENGINEERING
 LANDSCAPE ARCHITECTURE — SURVEYING
 7900 GLADES ROAD — SUITE 100
 BOCA RATON, FLORIDA 33434
 PHONE (561) 392-1991 / FAX (561) 750-1452

All County Paving
 DELRAY BEACH
 CONTEXT PHOTOS
 FLORIDA


DATE	04/04/24
DRAWN BY	GAH
F.B./ PG.	--
SCALE	--

Digitally signed by
 Gaylord Allan
 Hendricks
 Date: 2025.04.30
 08:54:48 -0400
 Adobe Acrobat
 version:
 2025.001.20435

G. ALLAN HENDRICKS
 LANDSCAPE ARCHITECT
 No. LA6666974
 STATE OF FLORIDA
 -FOR THE FIRM-

DATE

JOB # 10722
SHT.NO.
CON-2
OF 2 SHEETS

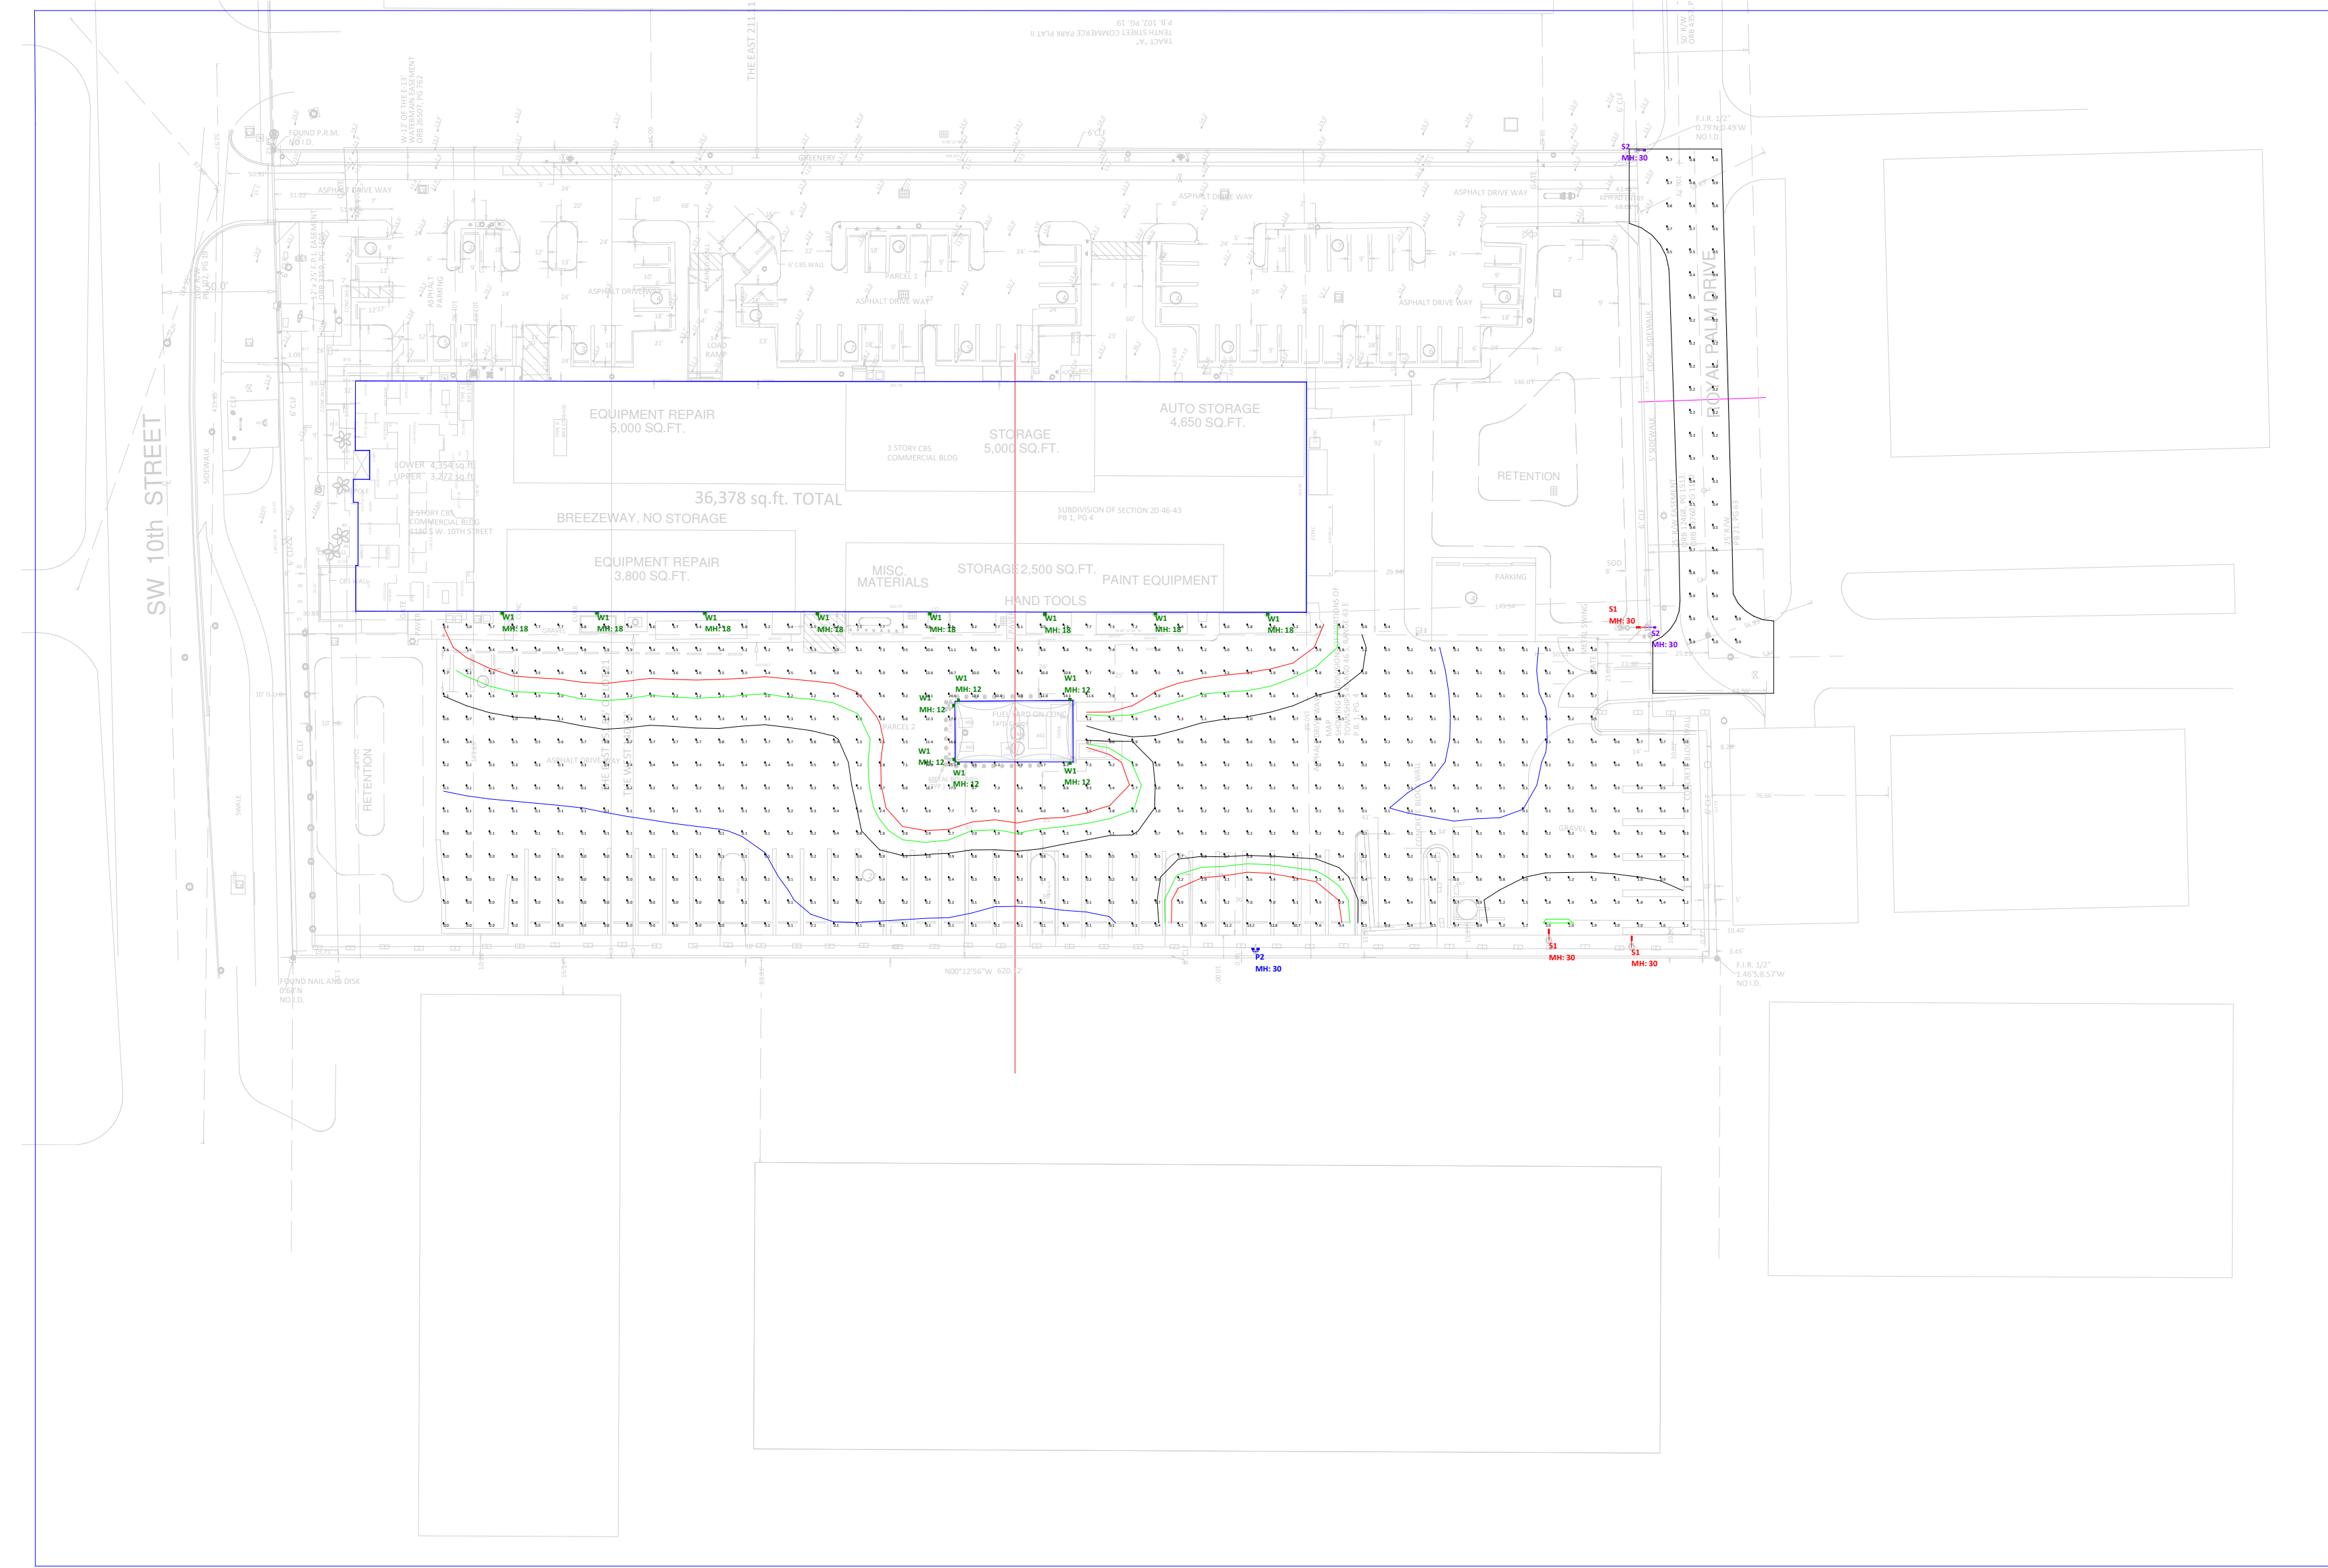



Scale: 1 inch= 55 Ft.

LIGHTING PARAMETERS:

Luminaire Schedule									
Symbol	Label	Qty	Arrangement	LLF	Description	Arr. Watts	Arr. Lum. Lumens	Mounting Height	[MANUFAC]
	P2	1	Twin	0.900	M100U3G-CSBKCR_4000K (Pole Flood) - 2x Heads on Bullhorns	181.18	25816	30	MaxLite Inc
	S1	3	Single	0.900	RS30L-30W_4000K_S (Solar Light)	30.52	5482	30	StreetLeaf
	S2	2	Single	0.900	ARCH-S-PA1-60-740-U-T3-59W	59	8328	30	COOPER LIGHTING SOLUTIONS
	W1	14	Single	0.900	M100U4W-CSBKCR_4000K (Wallpack)	90.59	12366	12, 18	MaxLite Inc

Calculation Summary									
Label	Units	Avg	Max	Min	Avg/Min	Max/Min	Grid Z	PtSpcLr	PtSpcTb
Parking and Drive	Fc	2.18	24.6	0.0	N.A.	N.A.	0	10	10
Royal Palm Drive	Fc	0.56	1.0	0.2	2.80	5.00	0	10	10

RENDER VIEWS:

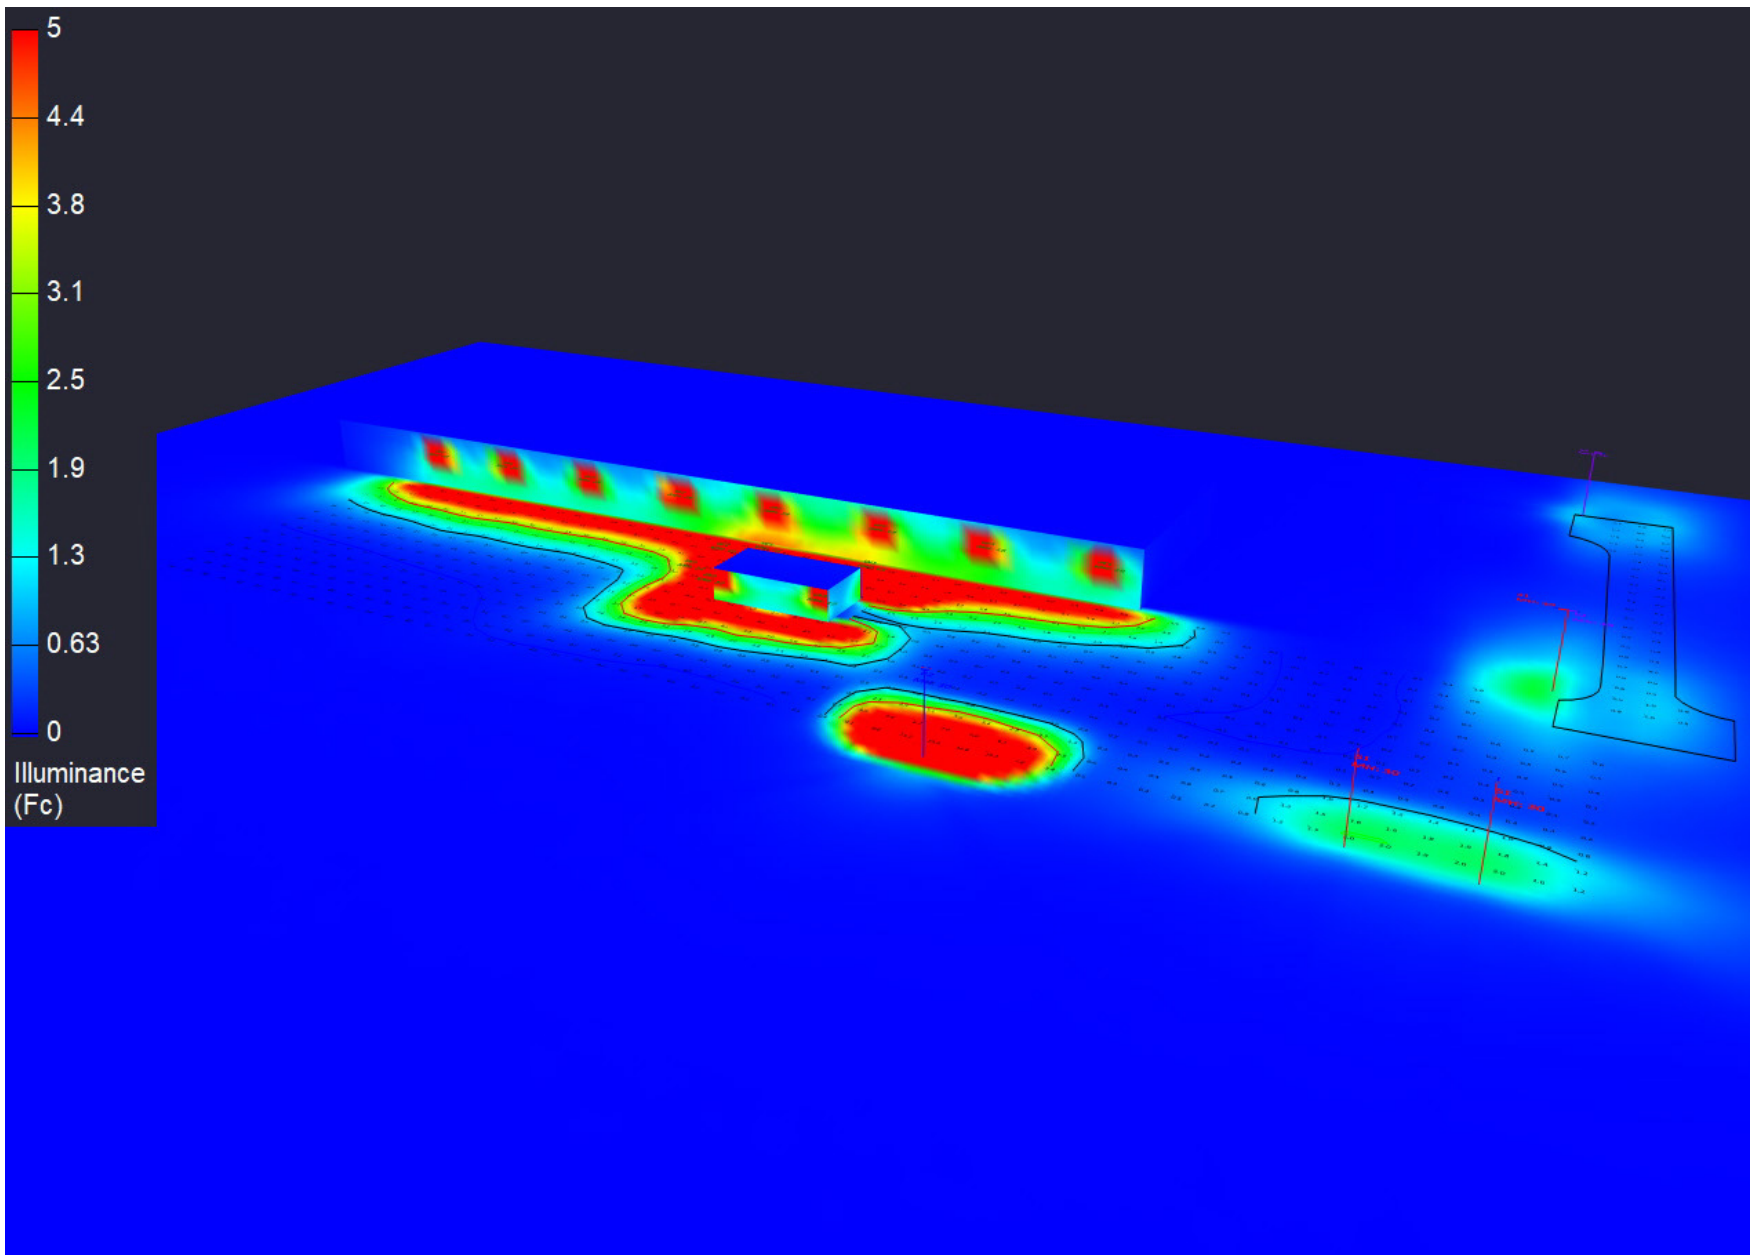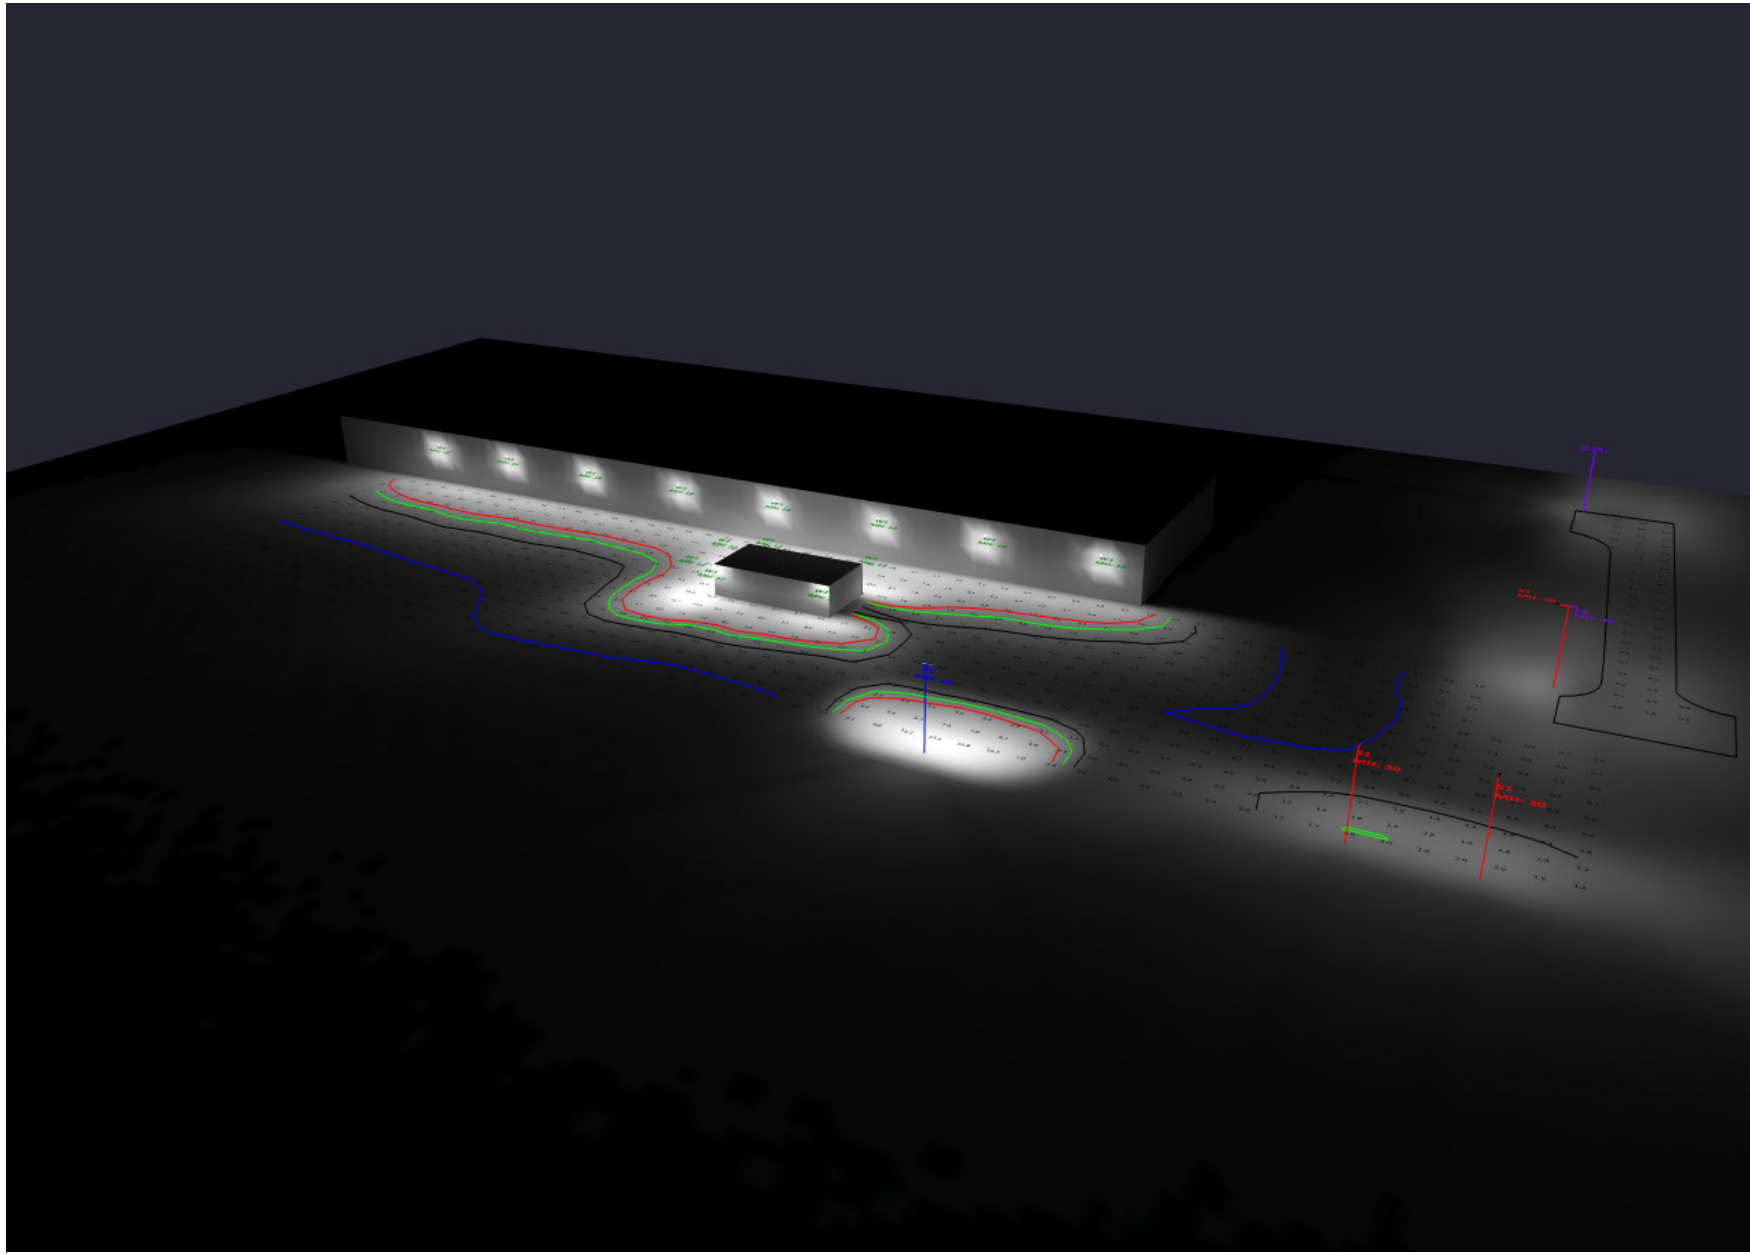

Design Notes:


Reflectances: 50%

Note on this Design:
This report makes no representations in regard to Lighting Design or Specification, rather it attempts to accurately reflect the photometric results of a design, as approved by others.

Note on these Photometric Calculations:
This analysis is a mathematical model and can be only as accurate as is permitted by the third-party software and the IES standards used. All digital CAD data appear to be accurate, however, this apparent accuracy is an artifact of the techniques used to generate it and is in no way intended to imply accuracy in the real world.


There are many factors that will impact the actual performance of Lighting in the constructed space, including: the accuracy of the original source (.ies) files supplied by the manufacturer, input voltage ballast variances, actual finish values in the constructed environment, manufacturing variations in both the source (lamp) and the luminaire, final luminaire placement, obstructions, and installation quality. Further, field measurement itself is subject to errors arising from measuring methods and/or technology selected, and the knowledge/ability of the measuring party. While the creator of this lighting study makes every effort to ensure accuracy, they cannot be held liable for any errors. The recipient of this lighting study understands and accepts that the likelihood of scaling error increases when no .DWG file or other properly-dimensioned drawing is provided to the designer.

NB: Reflective Values have a significant effect on light levels, the end-user of the document should confirm these values before accepting the results of any photometric report.

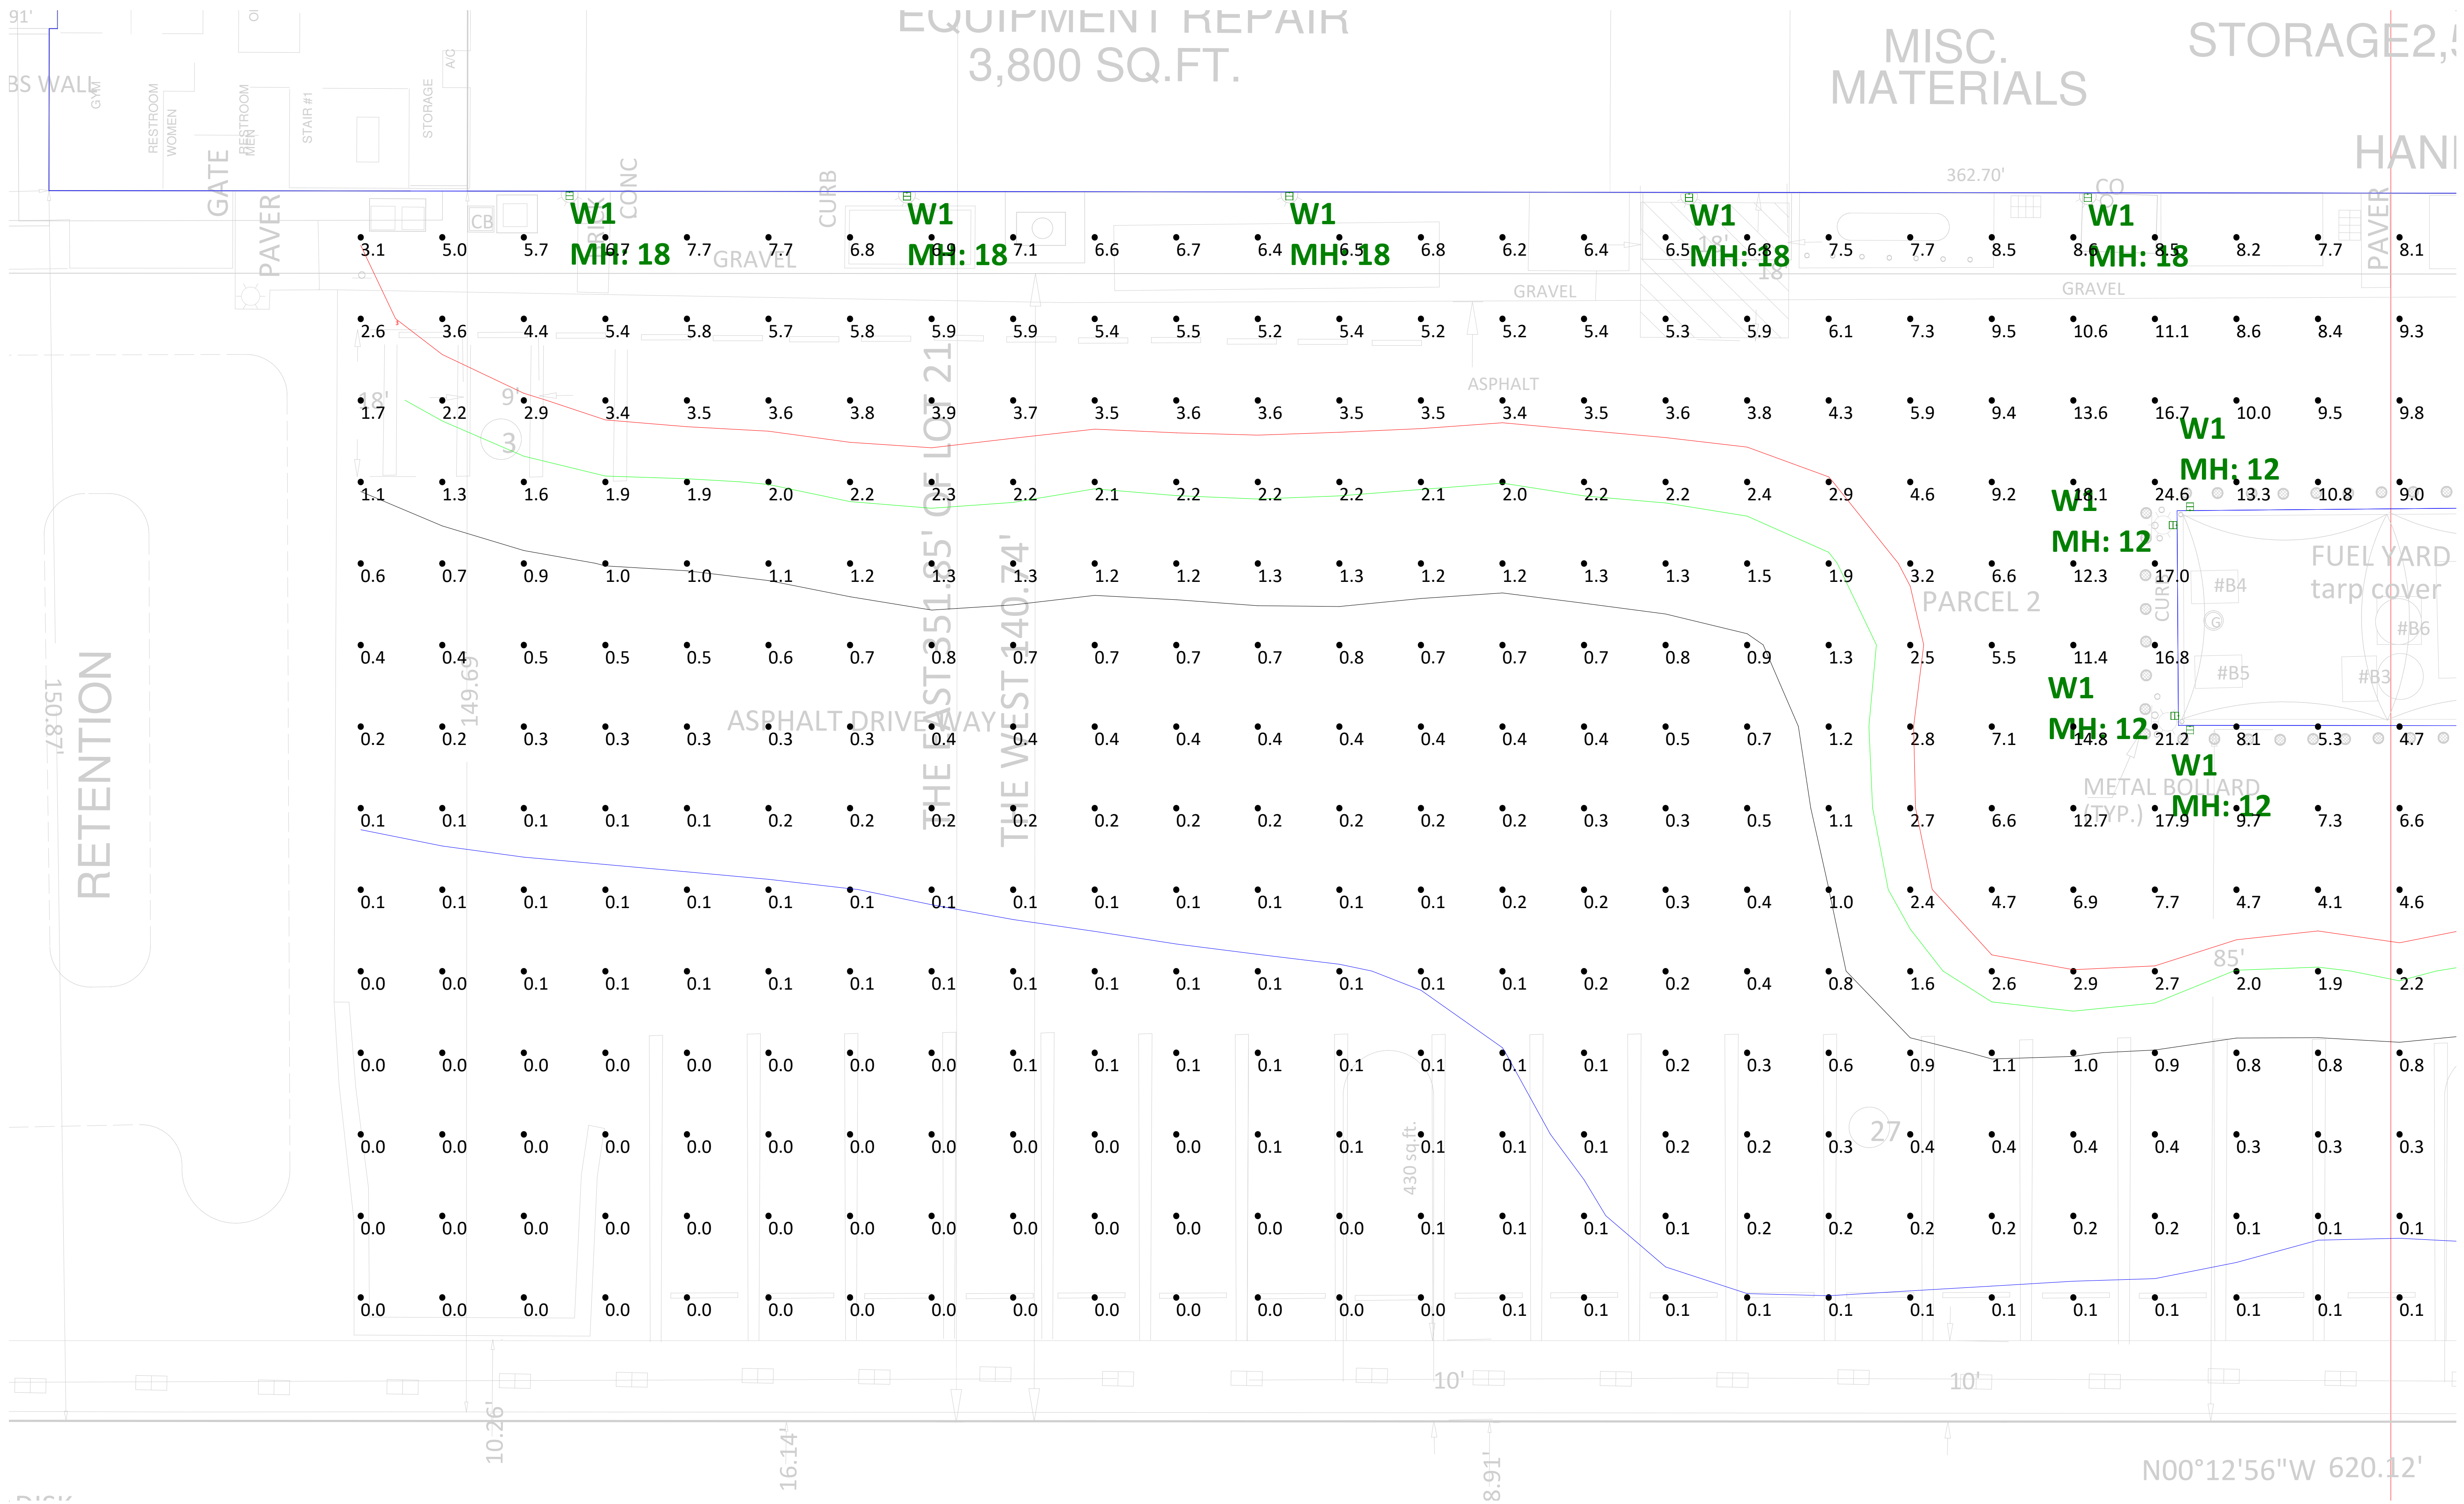

Scale: 1 inch= 10 Ft.


GE2,500 SQ.FT.
PAINT EQUIPMENT
HAND TOOLS

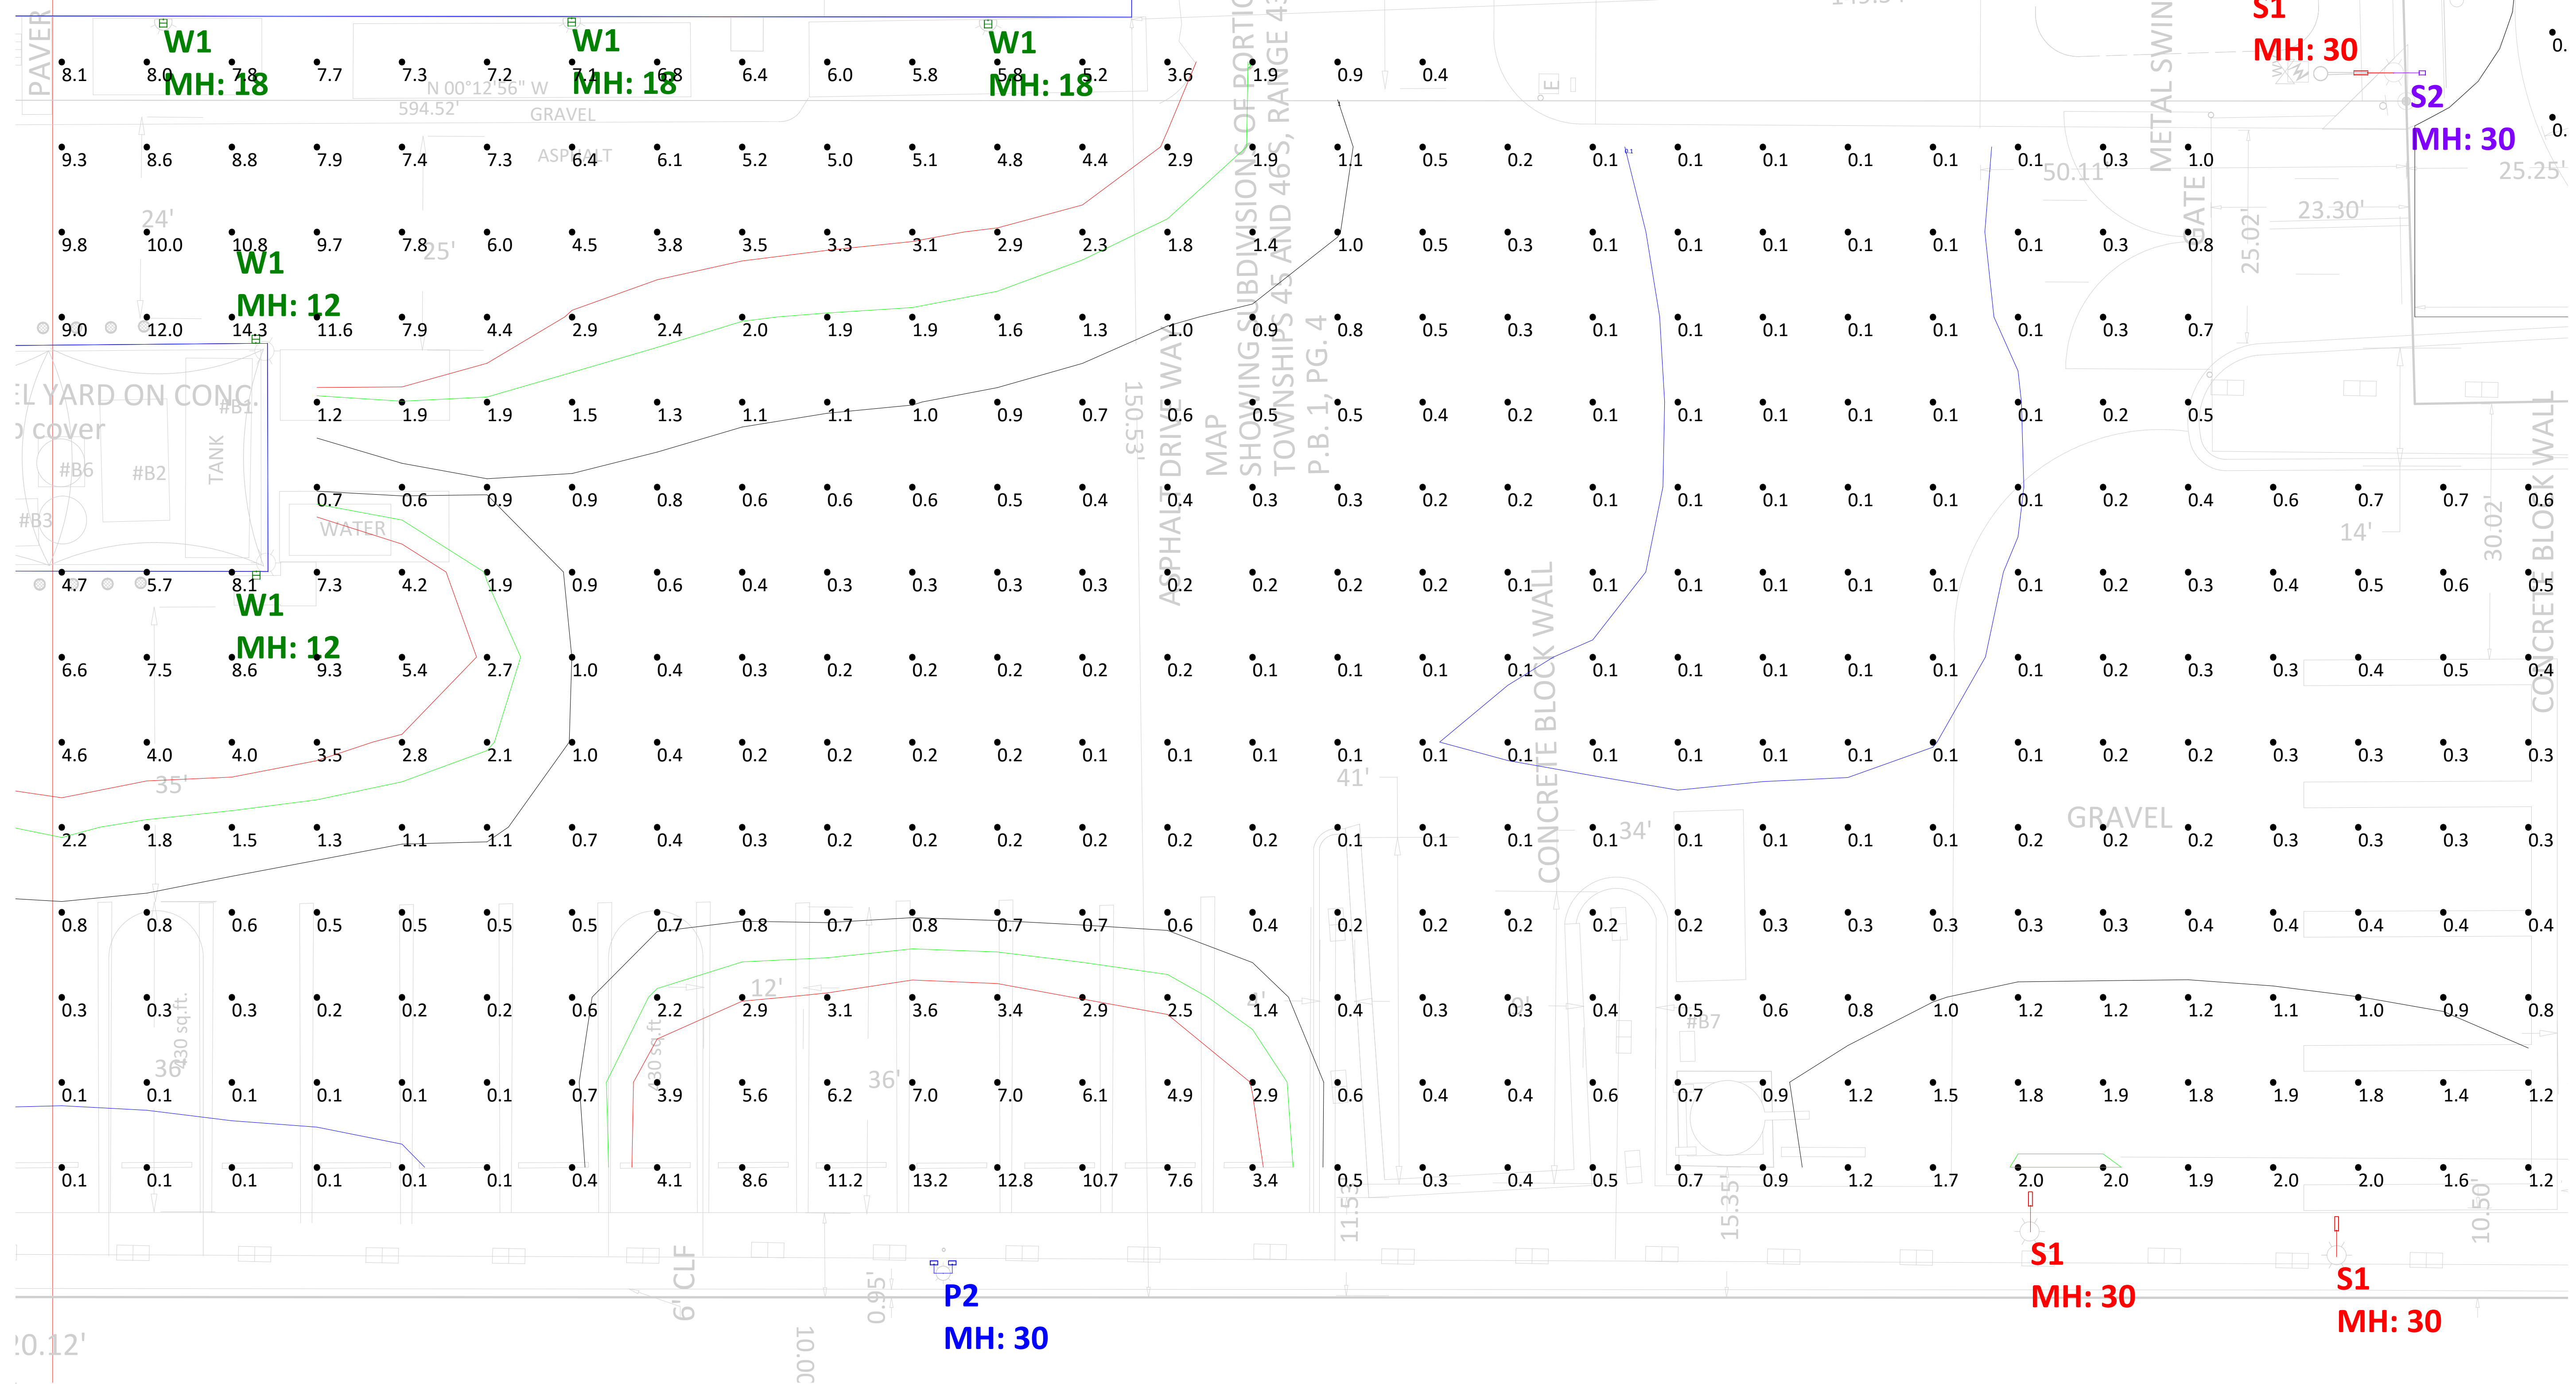

1180 SW 10th St, Delray Beach, FL
Site Lighting



Scale: 1 inch= 6 Ft.

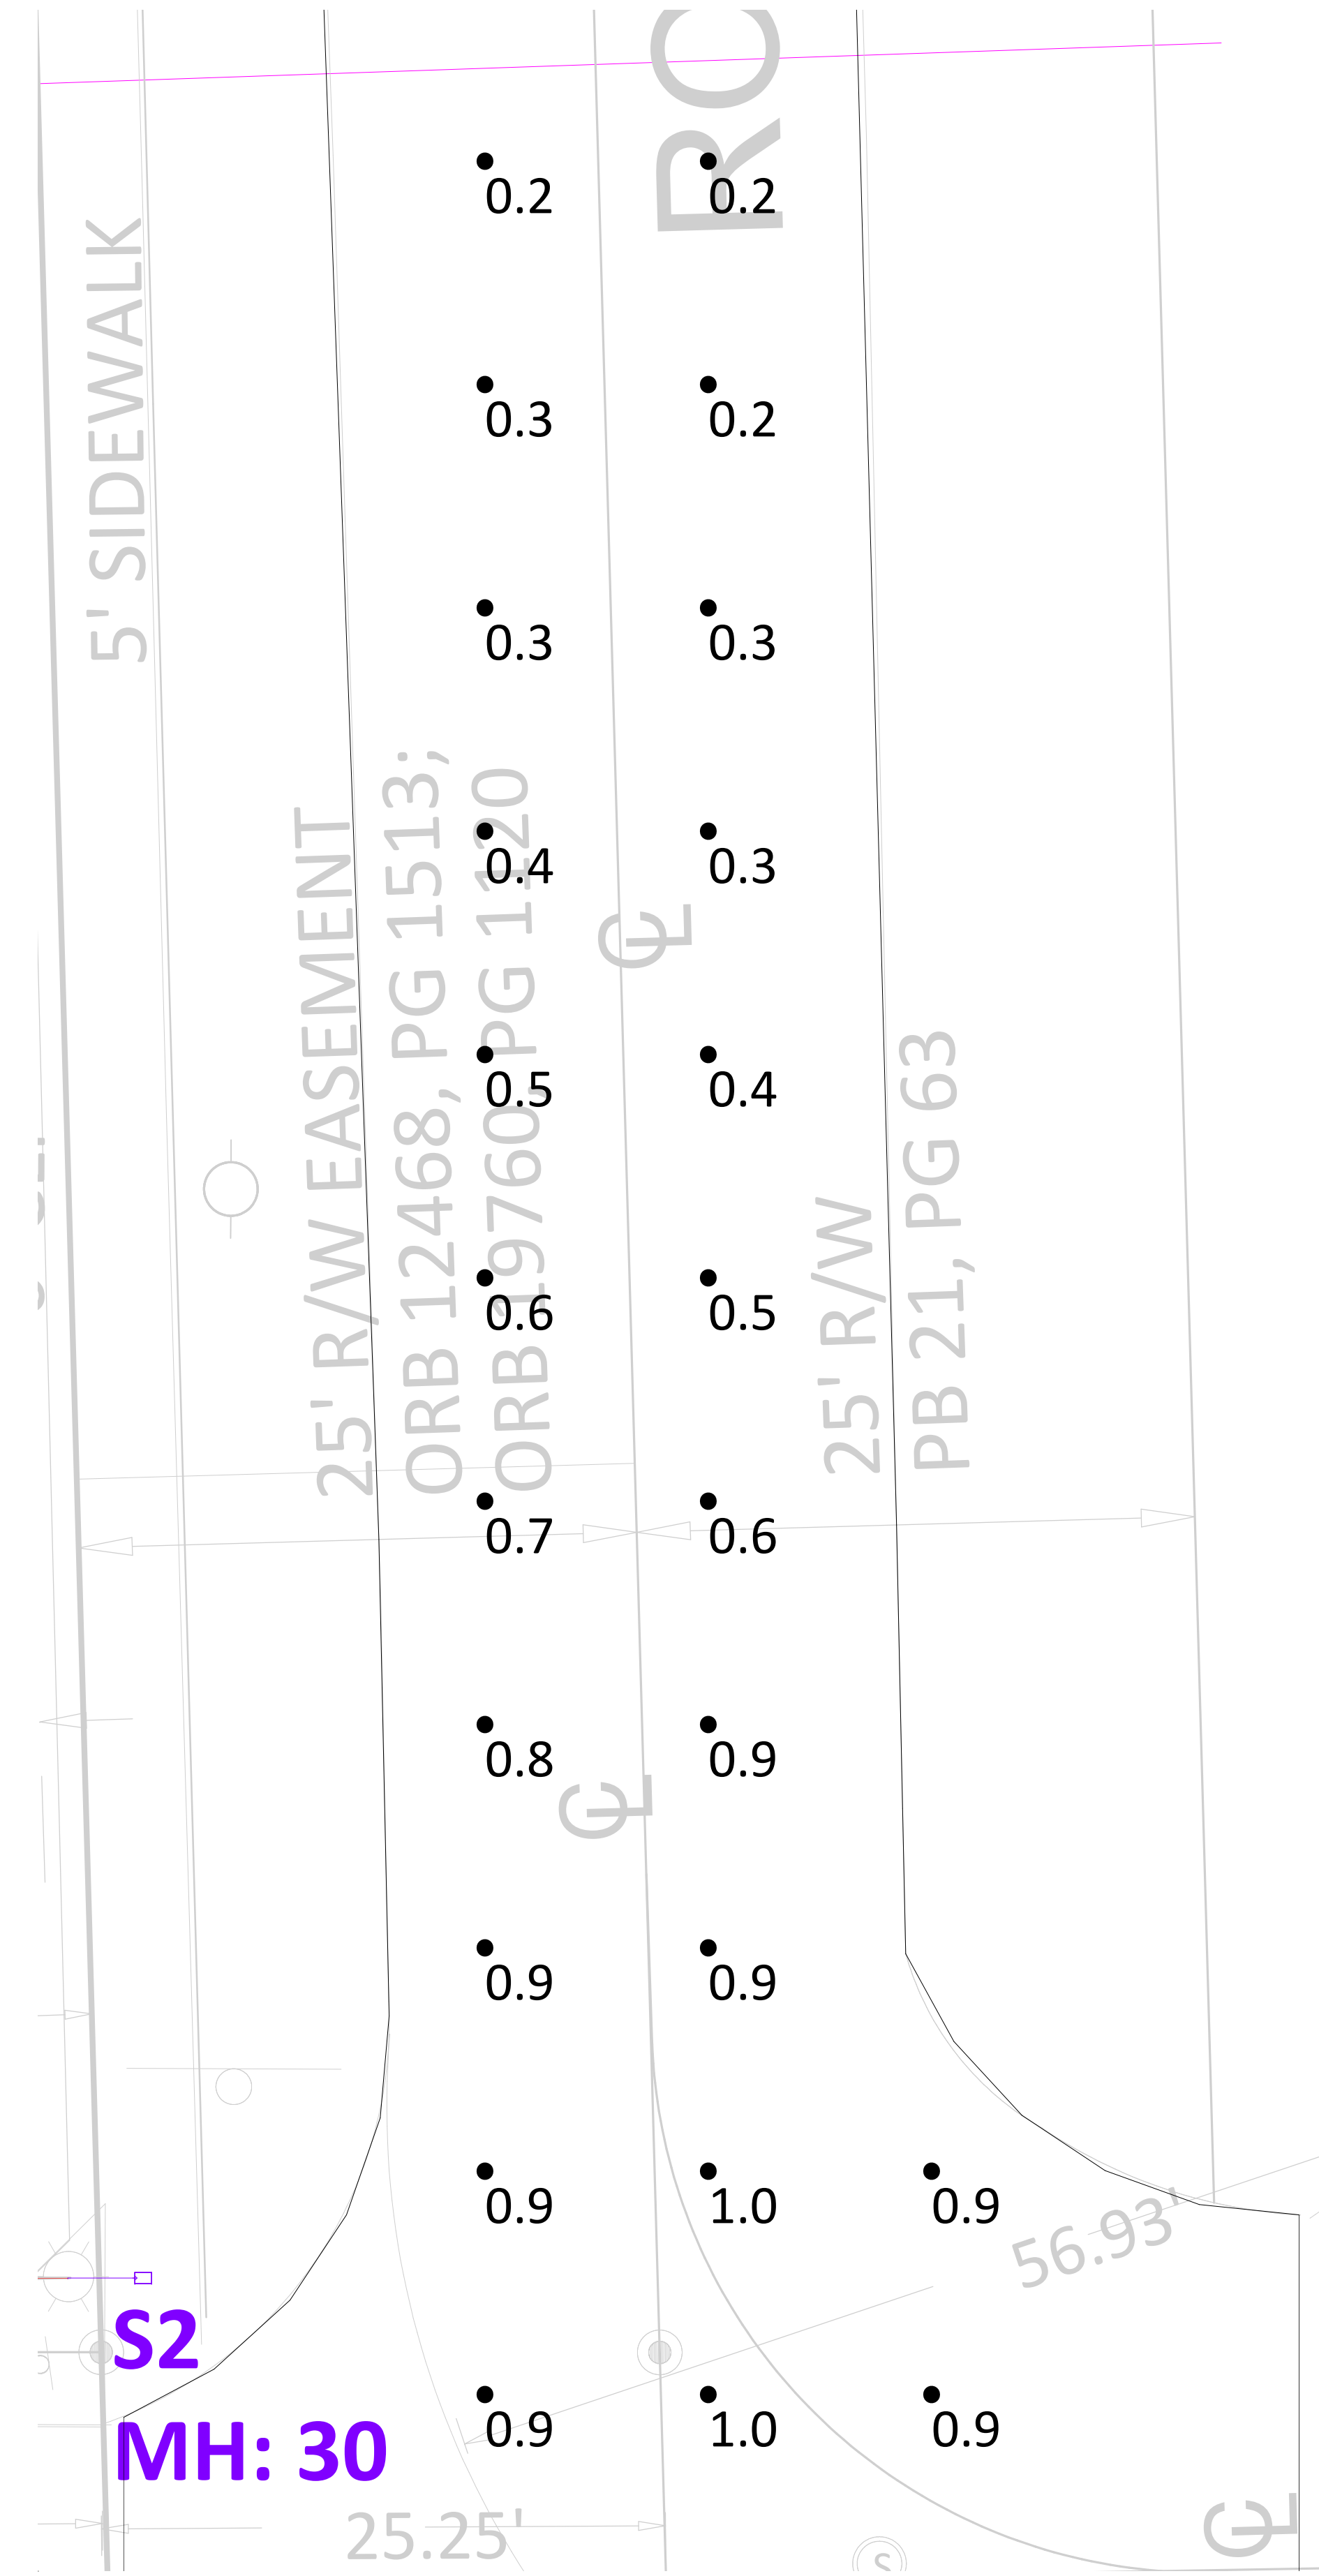

Scale: 1 inch= 6 Ft.



Autobahn Series ATBM Roadway


PRODUCT OVERVIEW



Applications:

Residential streets
Parking lots
High speed roadways

DIMENSIONS

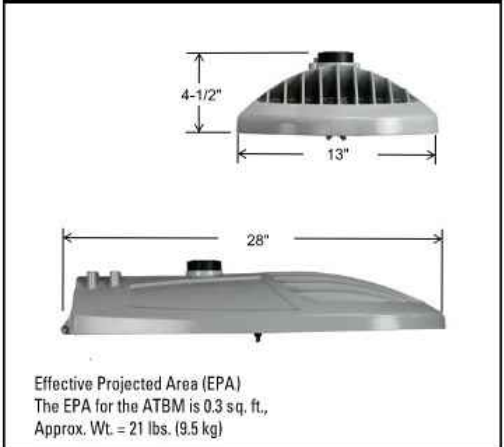

STANDARDS

Designlights Consortium® (DLC) Premium qualified product. Not all versions of this product may be DLC Premium qualified. Please check the DLC Qualified Products List at www.dlc.com to confirm which versions are qualified.

Color temperatures of $\leq 3000K$ must be specified for International Dark-Sky Association certification.

Rated for -40°C to 40°C ambient.

CSA Certified to U.S. and Canadian standards.

Complies with ANSI C136.2, C136.3, C136.4, C136.15, C136.15, C136.17.

GOVERNMENT PROCUREMENT – BAA – Buy American! Act: Product with the BAA option qualifies as a domestic end-product under the Buy American Act as implemented in the FAR and DFARS. Product with the BAA option also qualifies as manufactured in the United States under 501 Buy America regulations.

BABA – Buy American! Buy America: Product with the BAA option also qualifies as produced in the United States under the definitions of the Buy American, Buy America Act.

Please refer to www.aaculighting.com/buy-american for additional information.

Roadway Lighting

ATBM

Note: Specifications subject to change without notice.



Autobahn Series ATBM Roadway

ORDERING INFORMATION

ATBM	P05	MVOLT	R3	
Series	Lumen Package	Voltage	Optics	Mounting
ATBM Autobahn LED Roadway	P05 9,700 Lumens P10 11,000 Lumens P20 12,800 Lumens P30 15,500 Lumens P40 17,400 Lumens P50 18,700 Lumens P60 20,800 Lumens P70 21,500 Lumens	MVOLT Multi-volt, 120-277V 347 480 480V	R2 Roadway Type II R3 Roadway Type III R4 Roadway Type IV R5 Roadway Type V	(Blank) 2 Bolt Mounting 4B 4 Bolt Mounting

Options

Color Temperature (CCT)	Controls/Options	Accessories
(Blank) 4000K CCT, 70 CRI Min.	(Blank) 3 Pin NEMA Photocentral Receptacle	ATBMHS House Side Shield
27K 2700K CCT, 70 CRI Min.	P7 7 Pin Photocentral Receptacle (diminable driver included) ¹	ATBMLTS Light Tenon Shield
3K 3000K CCT, 70 CRI Min.	NR No Photocentral Receptacle	RKATBMVOLTSPD ATBM Acuity SPD, MVOLT
5K 5000K CCT, 70 CRI Min.	AD Field-Adjustable Output	RKATBMVOLTSPD ATBM Acuity SPD, 347/480V
Paint	PCSS Solid-State Lighting Photocentral ¹	RKATBMVOLTSPD ATBM MOV Pack, MVOLT
(Blank) Gray	PCLL Solid-State Long Life Photocentral	RKATBMVOLTSPD ATBM MOV Pack, 347/480V
BK Black	PCCC Solid-State Long Life Photocentral with remote control on/off ¹	
BR Bronze	SH Shorting Cap	UMR-X3 8" Horizontal Arm for Square Pole, Painted to match fixture
DB Dark Bronze		UMS-X3 8" Horizontal Arm for Round Pole, Galvanized
GI Graphite		UMR-GALV 8" Horizontal Arm for Round Pole, Galvanized
WH White		UMS-GALV 8" Horizontal Arm for Square Pole, Galvanized
Surge Protector	(Blank) Standard Pack	
(Blank) Standard 20kV/10kA SPD	JP Job Pack (36/pallet)	
MP MOV Pack		
Miscellaneous Options		
RSS House Side Shield		
NL NEMA Label Indicating Wattage		
XL Not CSA Certified – No Terminal Block Cover		
VR ¹ Dual Optic Visual Comfort		
BAA Buy American(n) Act and/or Buy America Bay America Qualified		

AEL American Electric Lighting
AEL Headquarters, One Lithonia Way, Conyers, Georgia 30012
www.americanelectriclighting.com Phone: 1-866-HOLDPHONE
(Email: techsupport@americanelectriclighting.com)
© 2014-2024 Acuity Brands Lighting, Inc. All Rights Reserved. 08/09/24

Warranty Two-year limited warranty. This is the only warranty provided and no other statements in this specification sheet create any warranty of any kind. All other express and implied warranties are disclaimed. Complete warranty terms located at: www.aaculighting.com/warranty

Note: Actual performance may differ as a result of end-use environment and application. All values are design or typical values, measured under laboratory conditions at 25 °C. Specifications subject to change without notice.

Please contact your sales representative for the latest product information.

ATBM




RSX2 LED Area Luminaire



Specifications

EPA (F4000):	0.69 ft ² (0.06 m ²)
Length:	29.3" (74.4 cm) (SPA mount)
Width:	13.4" (34.0 cm)
Height:	3.0" (7.6 cm) Main Body 7.2" (18.3 cm) Arm
Weight: (SPA mount)	30.0 lbs (13.6 kg)

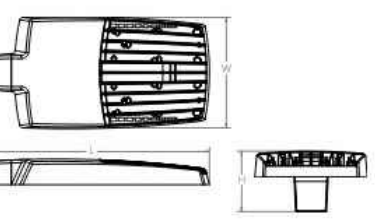

Introduction

The new RSX LED Area family delivers maximum value by providing significant energy savings, long life and outstanding photometric performance at an affordable price. The RSX2 delivers 11,000 to 31,000 lumens allowing it to replace 250W to 1000W HID luminaires.

The RSX features an integral universal mounting mechanism that allows the luminaire to be mounted on most existing drill hole patterns. This "no-drill" solution provides significant labor savings. An easy-access door on the bottom of mounting arm allows for wiring without opening the electrical compartment. A mast arm adaptor, adjustable integral splitter and other mounting configurations are available.



Items marked by a shaded background qualify for the Design Select program and ship in 15 days or less. To learn more about Design Select, visit www.aaculighting.com/designselect.
*See ordering tree for details.



Ordering Information

RSX2 LED	Performance Package	Color Temperature	Distribution	Voltage	Mounting
RSX2 LED	P1	30K 3000K	R2 Type 2 Wide	MVOLT (120V-277V)	SPA Square pole mounting (3.0" min. SD pole for 1" x 10", 3.0" min. SD pole for 2.3, 4, 4 x 10")
	P2	40K 4000K	R3 Type 3 Wide	MVOLT (120V-277V)	SPA Square pole mounting (3.0" min. SD pole for 1" x 10", 3.0" min. SD pole for 2.3, 4, 4 x 10")
	P3	50K 5000K	R4 Type 4 Wide	MVOLT (120V-277V)	SPA Square pole mounting (3.0" min. SD pole for 1" x 10", 3.0" min. SD pole for 2.3, 4, 4 x 10")
	P4		R5 Type 5 Wide	MVOLT (120V-277V)	SPA Square pole mounting (3.0" min. SD pole for 1" x 10", 3.0" min. SD pole for 2.3, 4, 4 x 10")
	P5		R6 Type 6 Wide	MVOLT (120V-277V)	SPA Square pole mounting (3.0" min. SD pole for 1" x 10", 3.0" min. SD pole for 2.3, 4, 4 x 10")
	P6		R7 Type 7 Wide	MVOLT (120V-277V)	SPA Square pole mounting (3.0" min. SD pole for 1" x 10", 3.0" min. SD pole for 2.3, 4, 4 x 10")

Options

Shipped installed	Shipped installed
PC Photocentral, button type 1"	PC Photocentral, button type 1"
PER7 Seven wire hard lock receptacle only (no controls)	PER7 Seven wire hard lock receptacle only (no controls)
SP Single box (120, 277, 547)	SP Single box (120, 277, 547)
SP200V 200V surge pack (200V standard)	SP200V 200V surge pack (200V standard)
FMO Field adjustable output	FMO Field adjustable output
IS 15' Integrated splitter (not available for external control control control control)	IS 15' Integrated splitter (not available for external control control control control)
DS Dual switching 1"	DS Dual switching 1"

Finish

Finish	Finish
DBBK Dark Bronze	DBBK Dark Bronze
DBBK Black	DBBK Black
DBBK Natural Aluminum	DBBK Natural Aluminum
DBBK White	DBBK White
DBBK Natural Dark Bronze	DBBK Natural Dark Bronze
DBBK Natural Dark Aluminum	DBBK Natural Dark Aluminum
DBBK Natural Dark Steel	DBBK Natural Dark Steel
DBBK Natural Dark Copper	DBBK Natural Dark Copper



One Lithonia Way • Conyers, Georgia 30012 • Phone: 1-800-705-SERV (7378) • www.aaculighting.com
© 2011-2024 Acuity Brands Lighting, Inc. All rights reserved.

Lithonia RSX2 Area LED Rev. 08/02/25 Page 1 of 9

Ordering Information

Accessories	Notes
RSX2 House side shield (includes 2-bolt)	Any Type 5 distribution is not available with WBA.
RSX2 House side shield (includes 4-bolt)	RSX2 House side shield is not available with WBA.
RSX2 House side shield (includes 6-bolt)	RSX2 House side shield is not available with WBA.
RSX2 House side shield (includes 8-bolt)	RSX2 House side shield is not available with WBA.
RSX2 House side shield (includes 10-bolt)	RSX2 House side shield is not available with WBA.
RSX2 House side shield (includes 12-bolt)	RSX2 House side shield is not available with WBA.
RSX2 House side shield (includes 14-bolt)	RSX2 House side shield is not available with WBA.
RSX2 House side shield (includes 16-bolt)	RSX2 House side shield is not available with WBA.
RSX2 House side shield (includes 18-bolt)	RSX2 House side shield is not available with WBA.
RSX2 House side shield (includes 20-bolt)	RSX2 House side shield is not available with WBA.
RSX2 House side shield (includes 22-bolt)	RSX2 House side shield is not available with WBA.
RSX2 House side shield (includes 24-bolt)	RSX2 House side shield is not available with WBA.
RSX2 House side shield (includes 26-bolt)	RSX2 House side shield is not available with WBA.
RSX2 House side shield (includes 28-bolt)	RSX2 House side shield is not available with WBA.
RSX2 House side shield (includes 30-bolt)	RSX2 House side shield is not available with WBA.
RSX2 House side shield (includes 32-bolt)	RSX2 House side shield is not available with WBA.
RSX2 House side shield (includes 34-bolt)	RSX2 House side shield is not available with WBA.
RSX2 House side shield (includes 36-bolt)	RSX2 House side shield is not available with WBA.
RSX2 House side shield (includes 38-bolt)	RSX2 House side shield is not available with WBA.
RSX2 House side shield (includes 40-bolt)	RSX2 House side shield is not available with WBA.
RSX2 House side shield (includes 42-bolt)	RSX2 House side shield is not available with WBA.
RSX2 House side shield (includes 44-bolt)	RSX2 House side shield is not available with WBA.
RSX2 House side shield (includes 46-bolt)	RSX2 House side shield is not available with WBA.
RSX2 House side shield (includes 48-bolt)	RSX2 House side shield is not available with WBA.
RSX2 House side shield (includes 50-bolt)	RSX2 House side shield is not available with WBA.
RSX2 House side shield (includes 52-bolt)	RSX2 House side shield is not available with WBA.
RSX2 House side shield (includes 54-bolt)	RSX2 House side shield is not available with WBA.
RSX2 House side shield (includes 56-bolt)	RSX2 House side shield is not available with WBA.
RSX2 House side shield (includes 58-bolt)	RSX2 House side shield is not available with WBA.
RSX2 House side shield (includes 60-bolt)	RSX2 House side shield is not available with WBA.
RSX2 House side shield (includes 62-bolt)	RSX2 House side shield is not available with WBA.
RSX2 House side shield (includes 64-bolt)	RSX2 House side shield is not available with WBA.
RSX2 House side shield (includes 66-bolt)	RSX2 House side shield is not available with WBA.
RSX2 House side shield (includes 68-bolt)	RSX2 House side shield is not available with WBA.
RSX2 House side shield (includes 70-bolt)	RSX2 House side shield is not available with WBA.
RSX2 House side shield (includes 72-bolt)	RSX2 House side shield is not available with WBA.
RSX2 House side shield (includes 74-bolt)	RSX2 House side shield is not available with WBA.
RSX2 House side shield (includes 76-bolt)	RSX2 House side shield is not available with WBA.
RSX2 House side shield (includes 78-bolt)	RSX2 House side shield is not available with WBA.
RSX2 House side shield (includes 80-bolt)	RSX2 House side shield is not available with WBA.
RSX2 House side shield (includes 82-bolt)	RSX2 House side shield is not available with WBA.
RSX2 House side shield (includes 84-bolt)	RSX2 House side shield is not available with WBA.
RSX2 House side shield (includes 86-bolt)	RSX2 House side shield is not available with WBA.
RSX2 House side shield (includes 88-bolt)	RSX2 House side shield is not available with WBA.
RSX2 House side shield (includes 90-bolt)	RSX2 House side shield is not available with WBA.
RSX2 House side shield (includes 92-bolt)	RSX2 House side shield is not available with WBA.
RSX2 House side shield (includes 94-bolt)	RSX2 House side shield is not available with WBA.
RSX2 House side shield (includes 96-bolt)	RSX2 House side shield is not available with WBA.
RSX2 House side shield (includes 98-bolt)	RSX2 House side shield is not available with WBA.
RSX2 House side shield (includes 100-bolt)	RSX2 House side shield is not available with WBA.


External Shields




Pole/Mounting Information

Accessories including bullhorns, cross arms and other adapters are available under the accessories tab at Lithonia's Outdoor Poles and Arms product page. Click here to visit Accessories.


Handhole Orientation

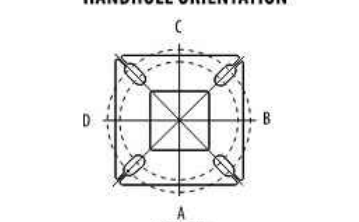

RSX POLE DRILLING

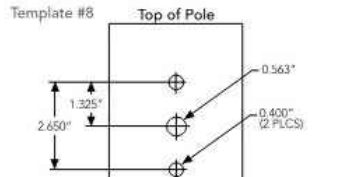


RSX STANDARD ARM & ADJUSTABLE ARM

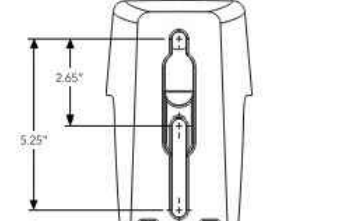

One Lithonia Way • Conyers, Georgia 30012 • Phone: 1-800-705-SERV (7378) • www.aaculighting.com
© 2011-2024 Acuity Brands Lighting, Inc. All rights reserved.

Lithonia RSX2 Area LED Rev. 08/02/25 Page 2 of 9

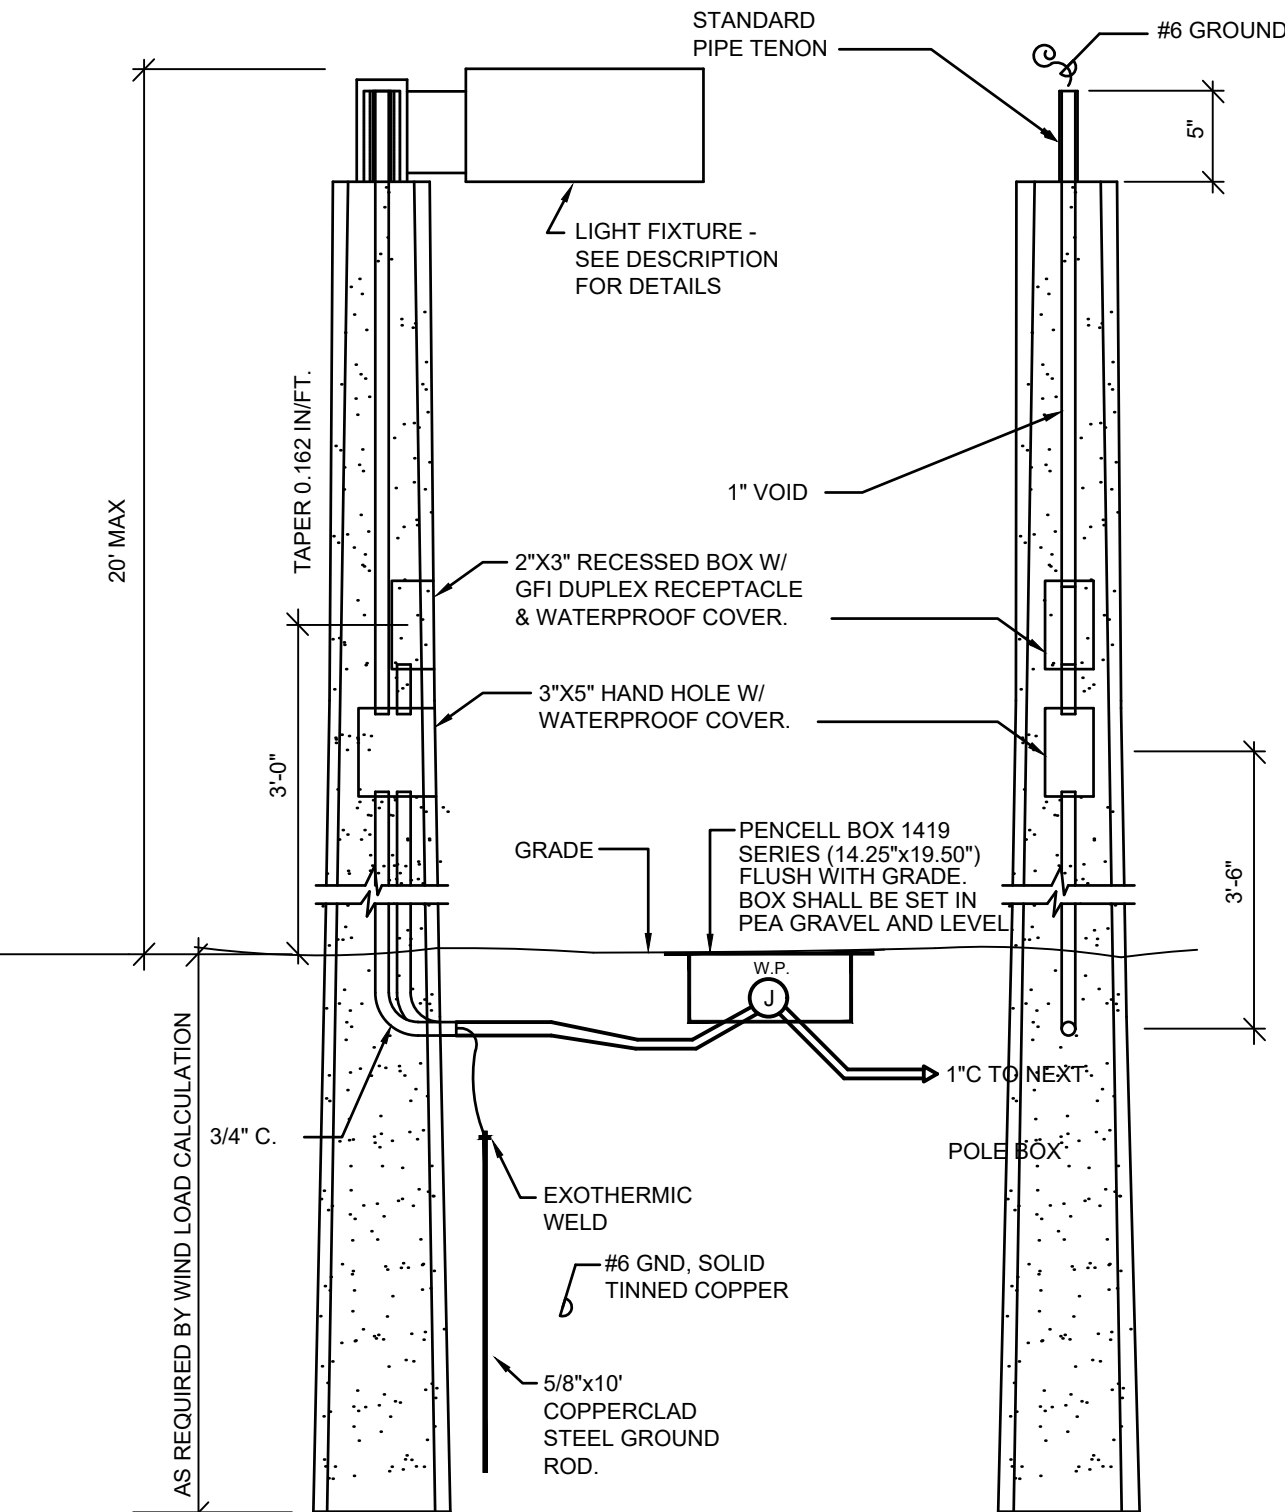


NOTE:
POLE SUPPLIER SHALL CERTIFY THAT POLE AND FIXTURE MEET THE FOLLOWING FBC WIND LOAD CRITERIA:
Vult = 215 MPH (3 SECOND GUST)
Vand = 170 MPH (3 SECOND GUST)
POLE SUPPLIER SHALL PROVIDE SIGNED & SEALED CALCULATIONS BY A FLORIDA STATE REGISTERED ENGINEER.

POLE LOCATION: SET BACK CENTER-LINE OF POLE SHALL BE 42 INCHES FROM THE CENTER-LINE OF PARKING STANDARD WHERE APPLICABLE. LOCATION OF ALL POLES MUST BE COORDINATED WITH ALL TRADES TO INSURE NO INTERFERENCES.

THE PHOTOMETRICS SHOWN ARE BASED ON LIGHT FIXTURES INDICATED ON THE LUMINAIRE SCHEDULE. THE CONTRACTOR IS RESPONSIBLE FOR PROVIDING FIXTURES INDICATED. IF THE CONTRACTOR SUBSTITUTES FIXTURES, THE CONTRACTOR IS RESPONSIBLE FOR PROVIDING POINT-BY-POINT CALCULATIONS FOR THE FIXTURES BEING SUBMITTED FOR APPROVAL.

FIXTURE A CONCRETE DIRECT BURIAL POLE DETAIL

N.T.S.

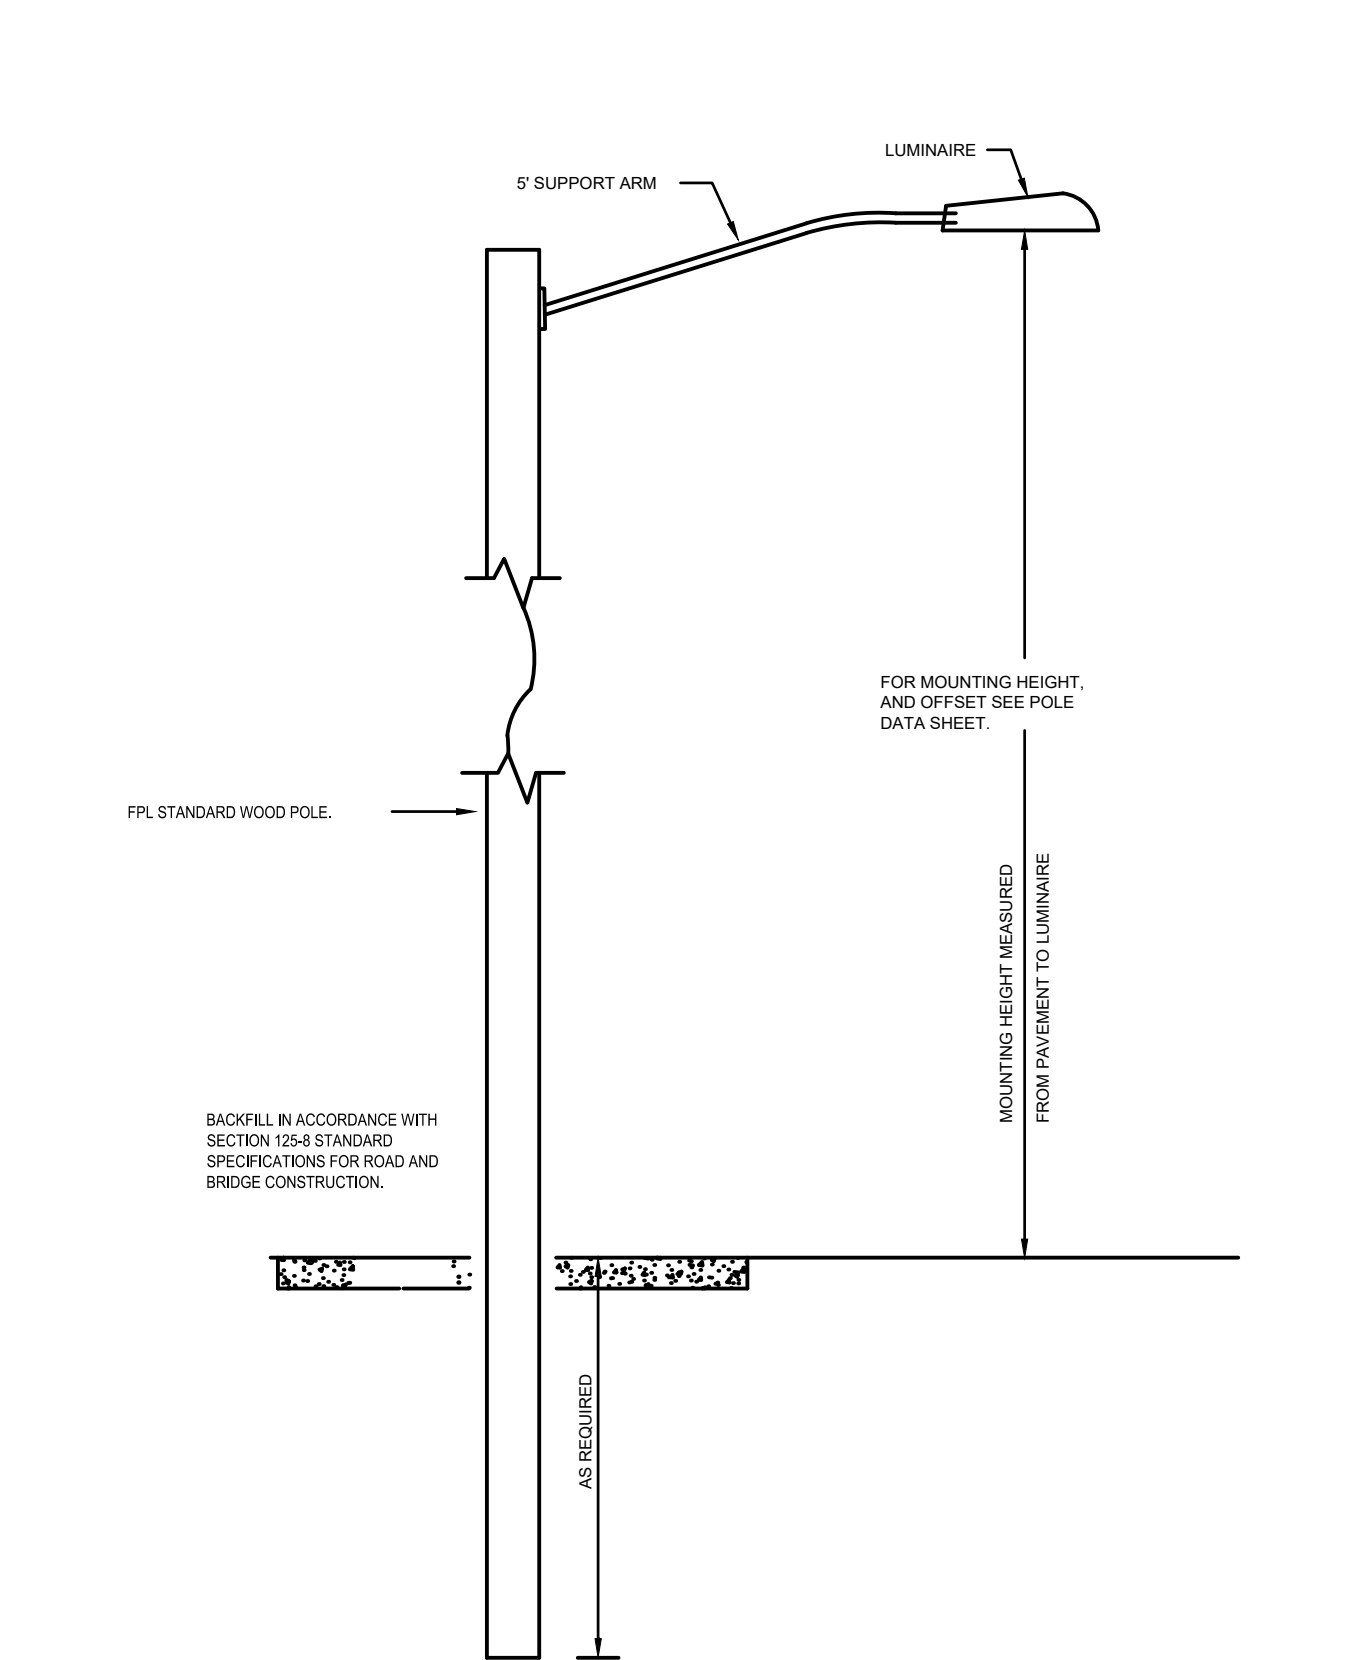

ROADWAY WOOD POLE DETAIL


NO SCALE

ALL COUNTY PAVING

FLORIDA

DELRAY BEACH

TYECO THOMPSON & YOUNGROSS
ENGINEERING CONSULTANTS, LLC
C.O.A. NO. 25996

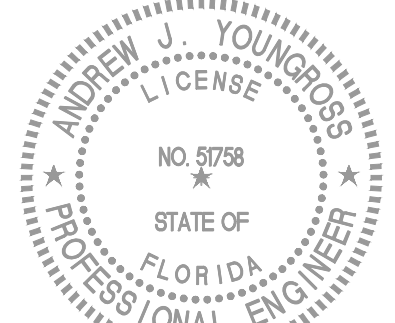

902 CLINT MOORE ROAD
SUITE 142
BOCA RATON, FLORIDA 33487
O: 561-274-0200
F: 561-274-0222
E: tec@tyeco.com
www.tyeco.com


THESE DRAWINGS ARE PREPARED PER ESTABLISHED INDUSTRY STANDARDS AND REPRESENT THE ENGINEERS DESIGN. PROVIDE EVERY DETAIL OR CONDITION FOR THE CONTRACTOR THROUGH THE BUILDING AND OTHER COORDINATION. ENGINEER IS COMPLETELY RESPONSIBLE FOR PROVIDING A COMPLETE AND OPERATIONAL BUILDING WHETHER INDICATED ON THE PLANS OR NOT.

Job Number 25068
Issued for: Permit 04-22-25

Design By: AJY
Drawn By: AJY
Checked By: AJY
Scale: AS NOTED

ES0.1

PHOTOMETRIC SITE PLAN

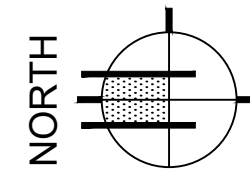
 $1''=30'$ 

PHOTOMETRIC NOTE

THE PHOTOMETRICS SHOWN ARE BASED ON LIGHT FIXTURES INDICATED ON LUMINAIRE SCHEDULE. THE CONTRACTOR IS RESPONSIBLE FOR PROVIDING FIXTURES INDICATED. IF THE CONTRACTOR SUBSTITUTES FIXTURES, THE CONTRACTOR IS RESPONSIBLE FOR PROVIDING POINT-BY-POINT CALCULATIONS FOR FIXTURES BEING SUBMITTED FOR APPROVAL.

Schedule									
Symbol	Label	QTY	Catalog Number	Description	Lamp	Number Lamps	Lumens per Lamp	LLF	Wattage
	SP4 HS	1	RSX2 LED P2 40K R4 HS	RSX LED Area Luminaire Size 2 P2 Lumen Package 4000K CCT Type R4 Distribution with HS shield	LED	1	11454	0.95	114.07
	R3	2	ATBM P05 R3 XXX VR 3K XXXXX	ATBM P05 Package 3000K Roadway Type III Dual Optix refractor	LED	1	8296	0.95	68
	SP4	11	RSX2 LED P2 40K R4	RSX Area Fixture Size 2 P2 Lumen Package 4000K CCT Type R4 Distribution	LED	1	17427	0.95	114.07

Statistics						
Description	Symbol	Avg	Max	Min	Max/Min	Avg/Min
ROADWAY	+	1.0 fc	2.2 fc	0.4 fc	5.5:1	2.5:1
STORAGE PARKING	+	2.0 fc	5.6 fc	1.0 fc	5.6:1	2.0:1
WEST PROPERTY LINE	+	0.6 fc	1.7 fc	0.0 fc	N/A	N/A

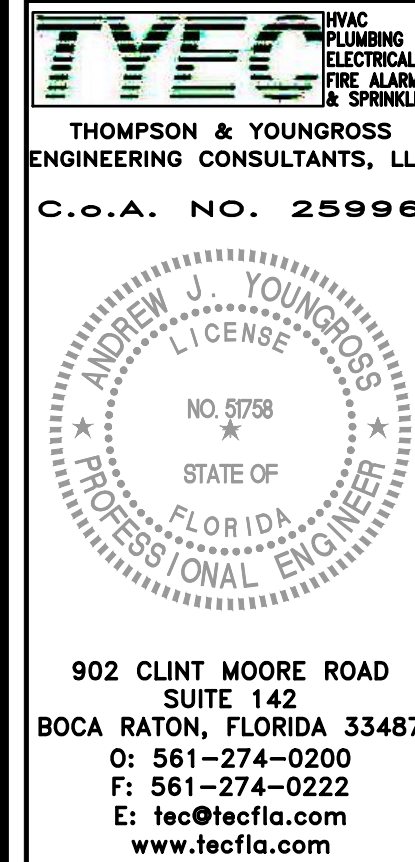



THESE DRAWINGS ARE PREPARED PER ESTABLISHED INDUSTRY STANDARDS AND REPRESENT THE ENGINEERS DESIGN CONCEPT. THEY ARE NOT INTENDED TO PROVIDE EVERY DETAIL OR CONDITION REQUIRED TO CONSTRUCT THE BUILDING. THE CONTRACTOR THROUGH SUBMITTAL AND OTHER COORDINATION EFFORTS IS FULLY RESPONSIBLE FOR PROVIDING COMPLETE AND OPERATIONAL BUILDING WHETHER INDICATED ON THE PLANS OR NOT.

Job Number	25068
Issued for:	
Permit	04-22-25

Design By: AJY
 Drawn By: AJY
 Checked By: AJY
 Scale : AS NOTED

ES1.1

ALL COUNTY PAVING - DRIVEWAY EXHIBIT

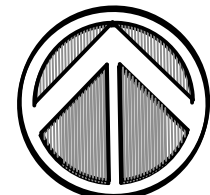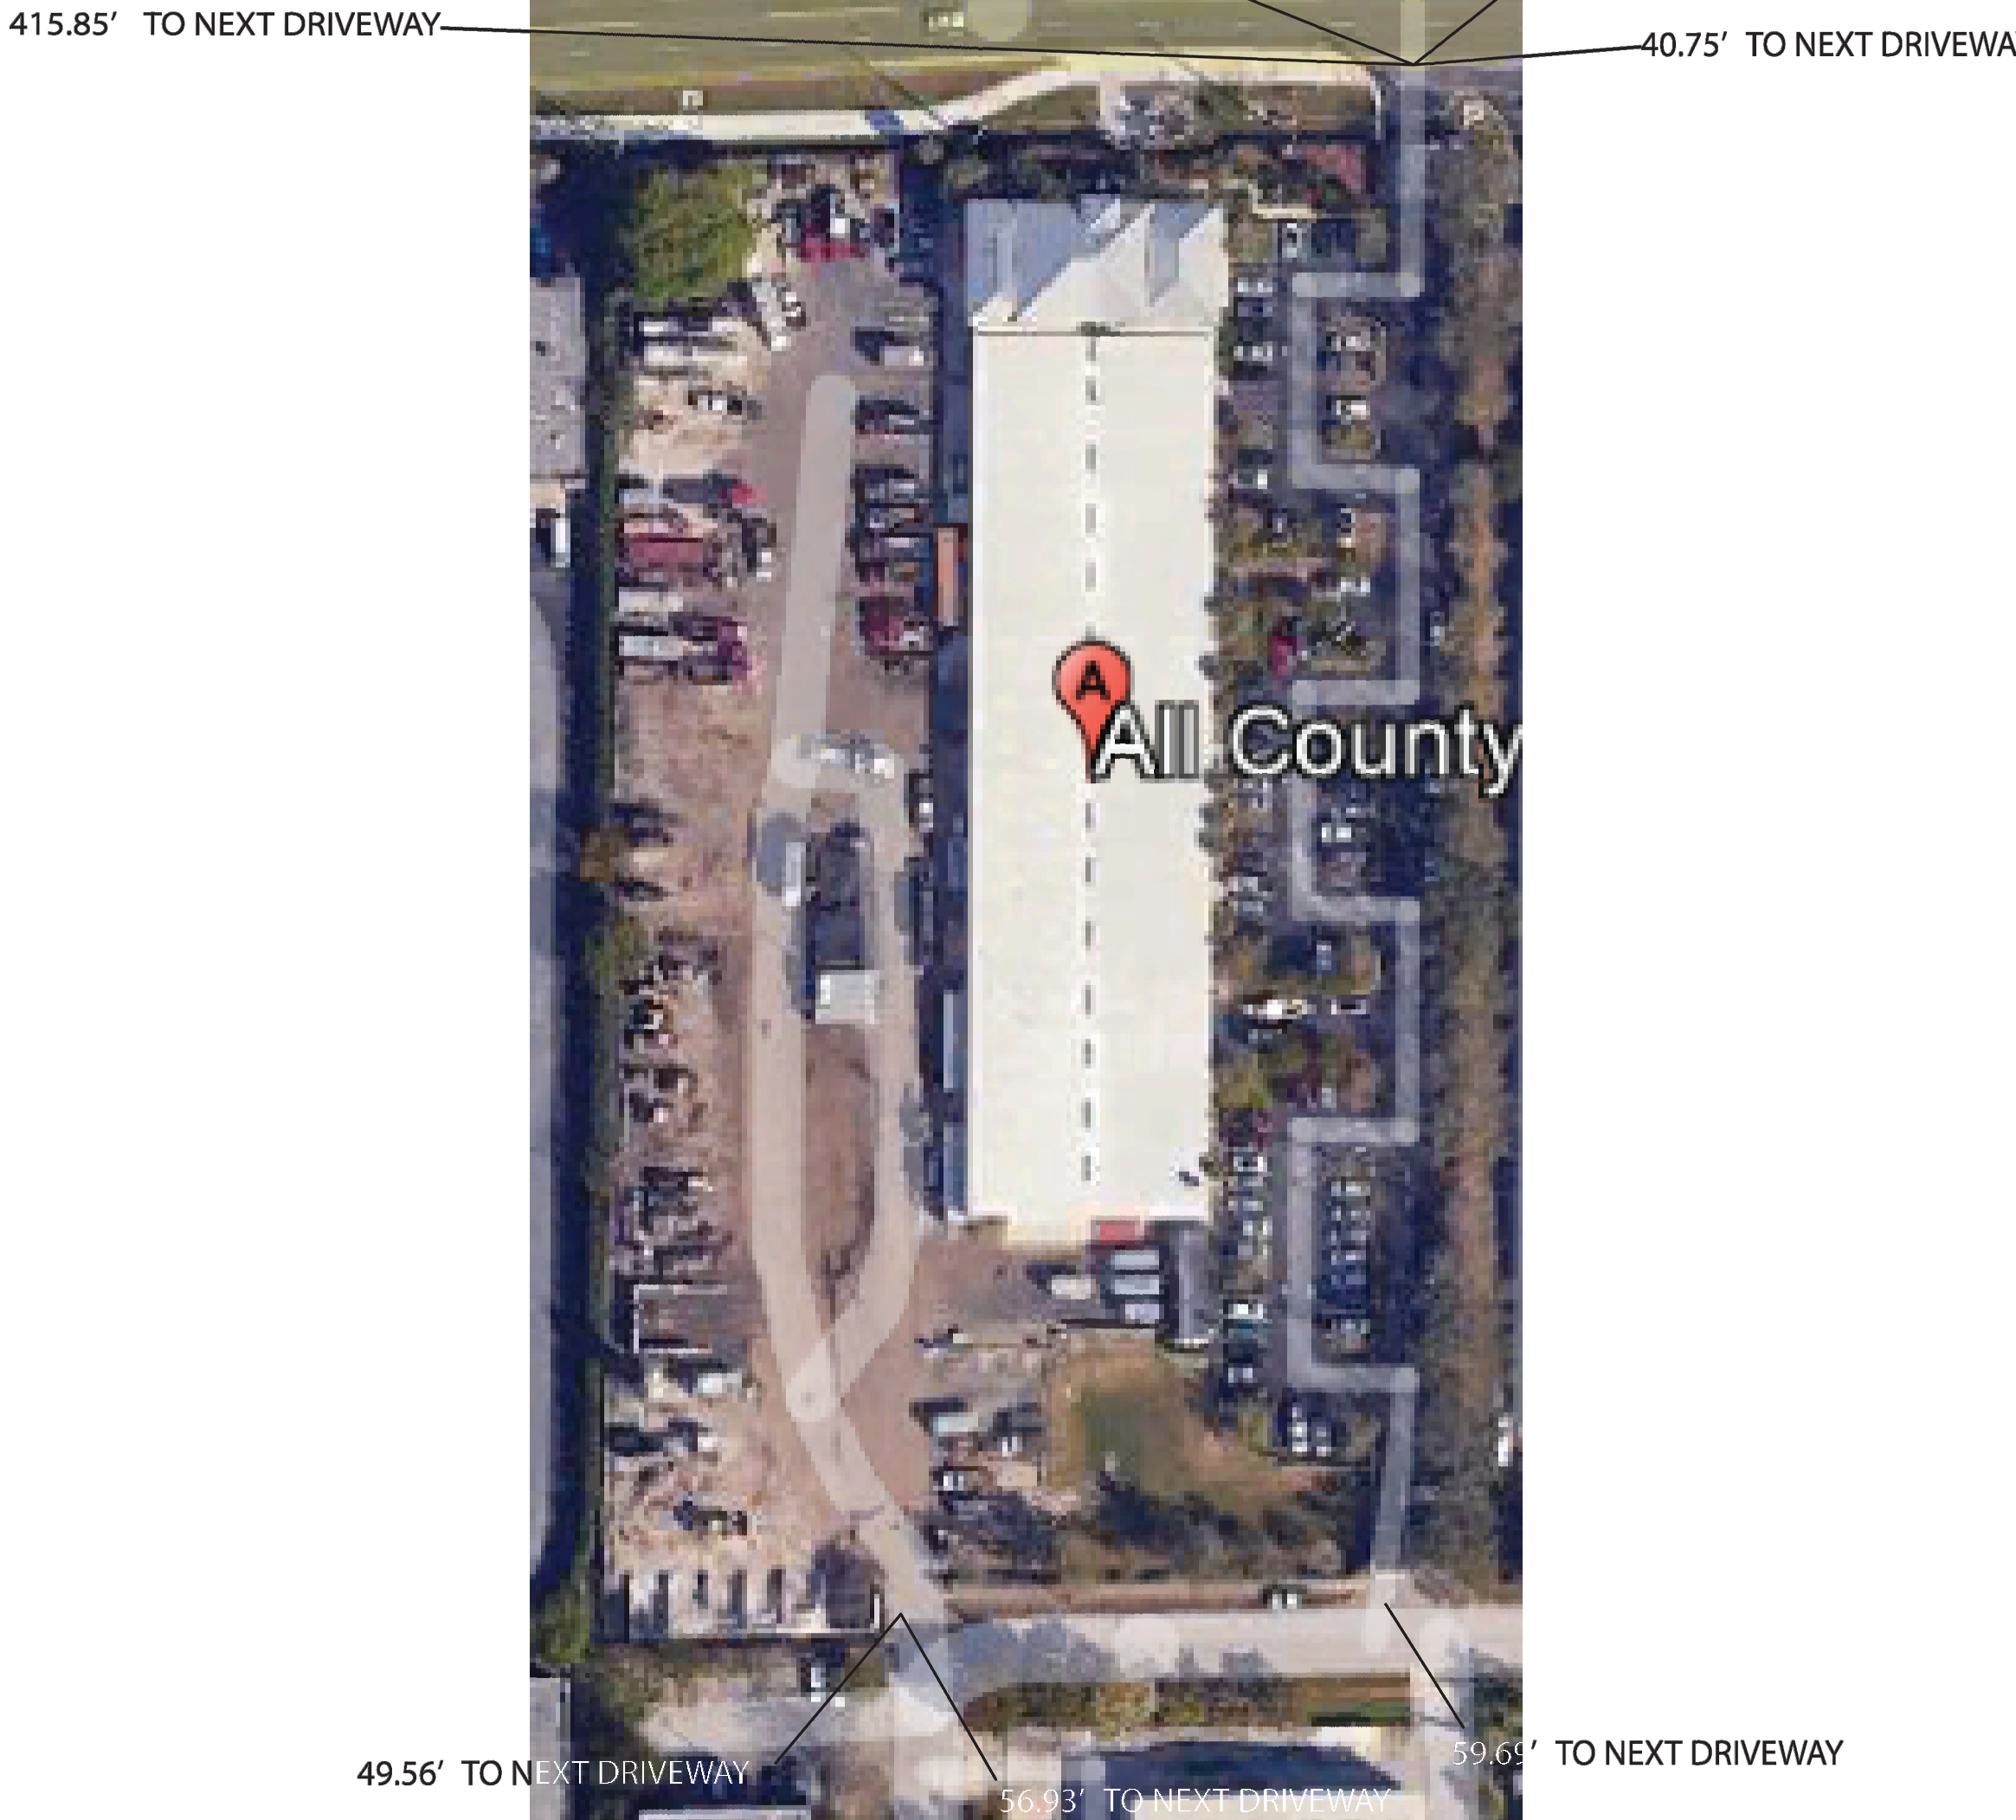

GRAPHIC SCALE

N.T.S.

[illegible]

CAULFIELD & WHEELER, INC.
CIVIL ENGINEERING
LANDSCAPE ARCHITECTURE — SURVEYING
7900 GLADES ROAD — SUITE 100
BOCA RATON, FLORIDA 33434
PHONE (561)-392-1991 / FAX (561)-750-1452

DELRAY BEACH DRIVEWAY EXHIBIT

ALL COUNTY PAVING

FLORIDA

DATE	04/24/25
DRAWN BY	GAH
F.B./ PG.	--
SCALE	--


 Digitally signed by
 Gaylord Allan
 Hendricks
 Date: 2025.04.30
 08:55:39 -04'00'
 Adobe Acrobat
 version:
 2025.001.20435

G. ALLAN HENDRICKS
 LANDSCAPE ARCHITECT
 No. LA6666974
 STATE OF FLORIDA
 -FOR THE FIRM-

DATE

JOB # 10722
SHT. NO. DE
OF 1 SHEETS