

FLOOR PLAN NOTES LEGEND



- 1 PLASTIC LAMINATE CABINET & TOP BY MILLWOK CONTRACTOR
- 2 PLASTIC LAMINATE WALL CABINET BY MILLWOK CONTRACTOR
- 3 PLASTIC LAMINATE COUNTER WITH SUPPORT BRACKETS BY MILLWOK CONTRACTOR
- 4 RECESSED SCALE - SEE DETAIL ON I/A-6.1
- 5 BENCH SEATING BY MILLWOK CONTRACTOR. SEE DETAIL I2/A-6.2
- 6 REFRESHMENT CENTER WITH BOTTLED WATER.
- 7 PLASTIC LAMINATE RECEPTION DESK WITH TRANSACTION COUNTER BY MILLWOK CONTRACTOR
- 8 36" (MIN) LONG BY 36" HIGH ADA ACCESSIBLE COUNTER
- 9 TREATMENT ISLAND - SEE SIMILAR DETAILS IO AND II ON A-6.4 FOR MORE INFORMATION
- 10 36" WIDE PACKPASS BY MILLWOK CONTRACTOR - SEE DETAIL I/A-6.2
- 11 DASHED LINE INDICATES "NOISE AND ODOR" SEPARATION WALL
- 12 28" DEEP ANIMAL CAGE BANK - VERIFY SIZE & SELECTION WITH OWNER, ON 4" H X 30" D RAISED CONC. CURB. SEE DETAILS I, 2 & 3 ON A-6.1
- 13 INTERIOR DOG RUN BY MASON COMPANY OR EQUAL - VERIFY STYLE AND SIZE WITH OWNER.
- 14 VETERINARY EQUIPMENT - VERIFY AND COORDINATE WITH OWNER. SEE EQUIPMENT SCHEDULE ON A-8.0 FOR MORE INFORMATION
- 15 COMMERCIAL WASHER AND DRYER - VERIFY APPLIANCES W/ G.C. AND OWNER.
- 16 HOT WATER HEATER LOCATION - SEE PLUMBING DRAWINGS FOR MORE INFORMATION.
- 17 HOP SINK BY CONTRACTOR - SEE DETAIL 4/A-6.1 FOR MORE INFORMATION
- 18 APPROXIMATE LOCATION DENTAL X-RAY EQUIPMENT - VERIFY EXACT LOCATION WITH OWNER. SEE DETAIL I/A-6.2 FOR MOUNTING DETAIL. VERIFY W/ MANUF.
- 19 ELECTRICAL PANEL LOCATION - SEE ELECTRICAL DRAWINGS FOR MORE INFORMATION
- 20 SEMI-RECESSED FIRE EXTINGUISHER CABINET COORDINATE W/ FIRE DEPT - SEE DETAIL 6/A-6.2 FOR MOUNTING INFORMATION.
- 21 REFRIGERATOR - VERIFY ALL APPLIANCES WITH OWNER AND G.C.
- 22 FREEZER - VERIFY ALL APPLIANCES WITH OWNER AND G.C.
- 23 FURNACE LOCATION - SEE MECHANICAL PLANS FOR MORE INFORMATION AND CONDENSER LOCATIONS
- 24 PROVIDE GENDER NEUTRAL SIGNAGE AT BATHROOM AND MEETS ADA SIGNAGE REQUIREMENTS. SEE ADA FIGURES ON A-9.1 FOR TACTILE SIGNAGE INFORMATION AND HEIGHTS.
- 25 PROVIDE/REPLACE SIGNAGE GRAPHICS/PANELS IN EXISTING MONUMENT SIGN

GENERAL FLOOR PLAN NOTES

1. WALLS ARE INDICATED WITH NOMINAL DIMENSIONS. REFER TO PARTITION TYPES A-6.0 FOR ACTUAL DIMENSIONS AND WALL THICKNESS.
2. DIMENSIONS ARE TO THE FACE OF GYPSUM BOARD, CONCRETE BLOCK, FACE OF METAL CLADDING, AND/OR OUTSIDE EDGE OF DOOR FRAME, UNLESS NOTED OTHERWISE.
3. REFER TO THE ENLARGED PLANS ON SHEET A-2.0 FOR ADDITIONAL DIMENSIONS AND NOTES.
4. REFER TO SHEET A-0.1 FOR LIFE SAFETY INFORMATION.
5. REFER TO SHEET A-0.0 FOR GENERAL NOTES THAT PERTAIN TO THE FLOOR PLANS.
6. REFER TO SHEET A-8.0 FOR EQUIPMENT PLAN AND INTERIOR ELEVATION TAGS
7. REFER TO SHEETS A-9.0 AND A-9.1 FOR ACCESSIBILITY SPECIFICATIONS, GUIDELINES AND FIGURES.

WALL LEGEND

- EXISTING WALL
 - NEW WALL
- NOTE: SEE A-6.0 FOR PARTITION TYPES

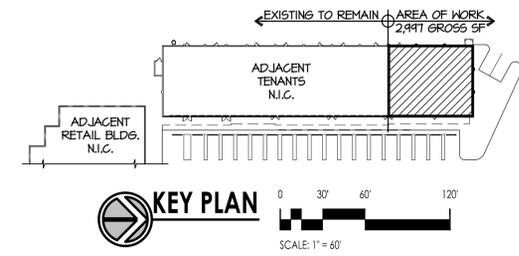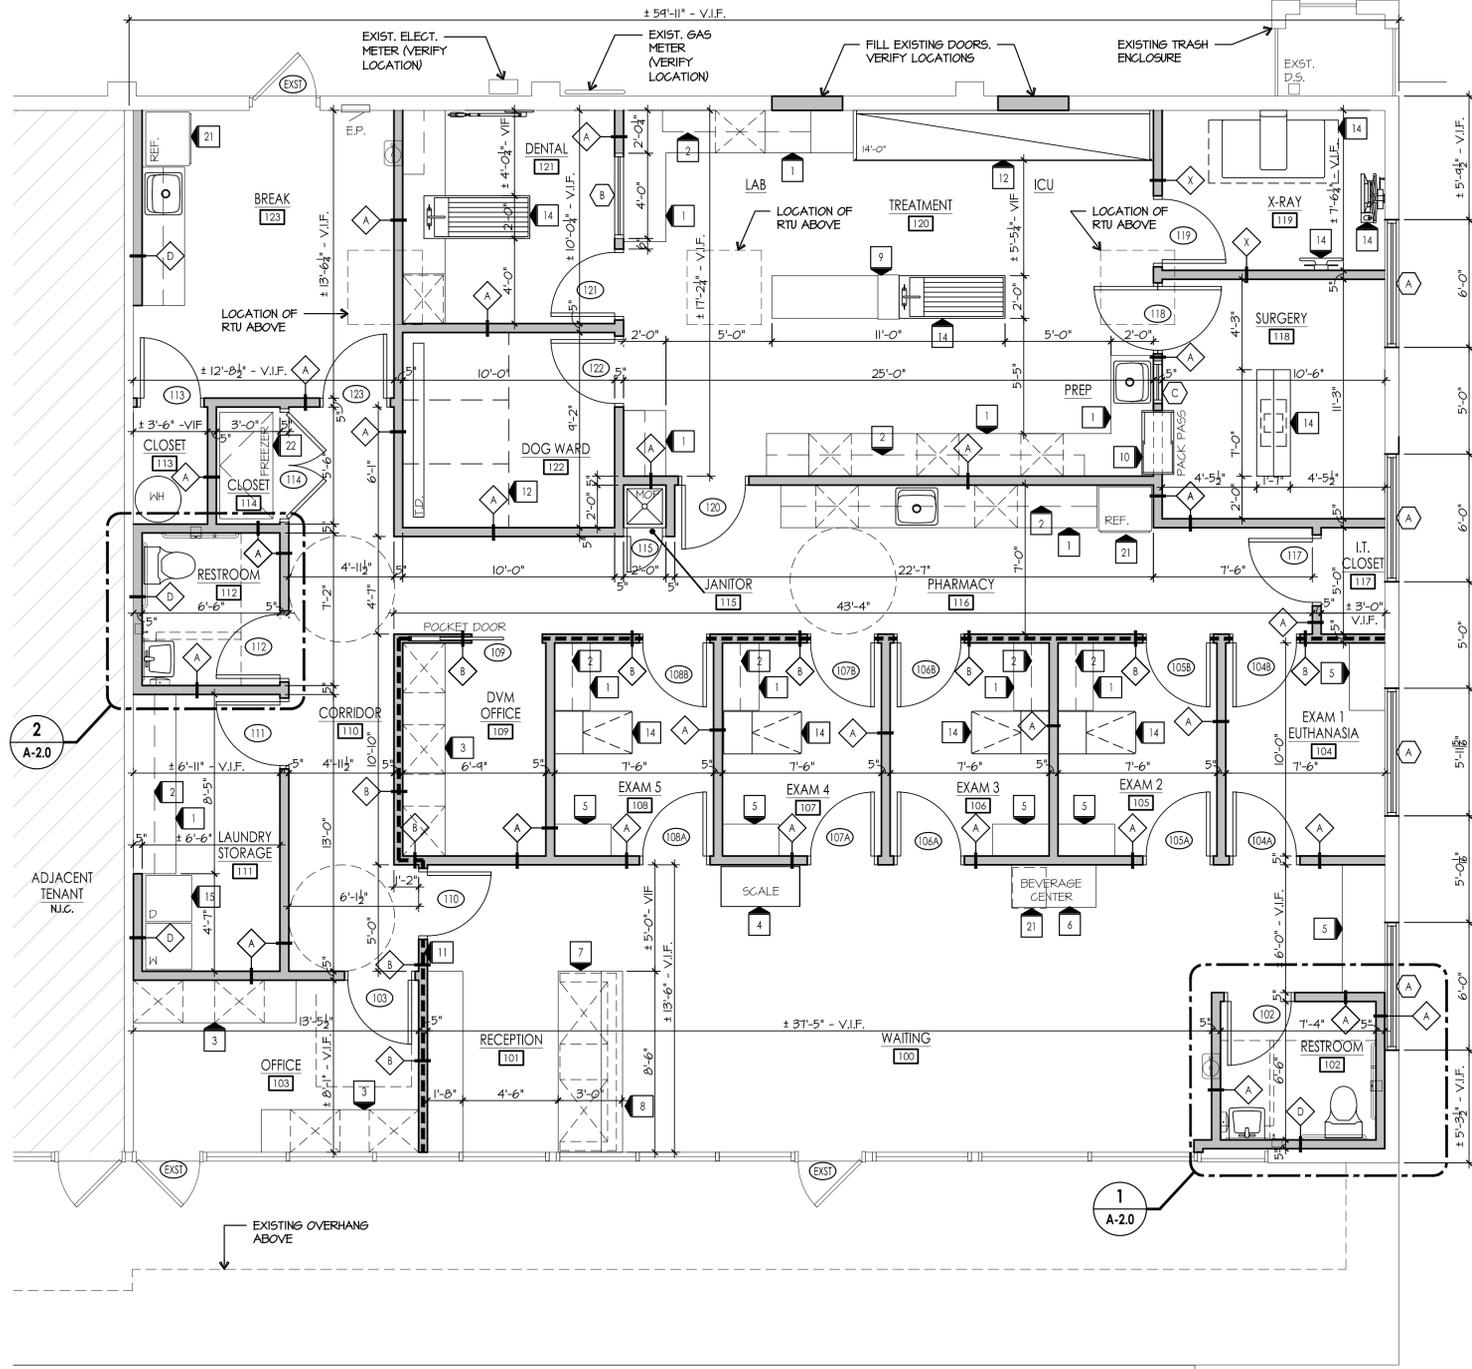

FIRST FLOOR PLAN
SCALE: 1/4" = 1'-0"




ARCHITECTURE
LAND PLANNING
INTERIOR ARCHITECTURE
LANDSCAPE ARCHITECTURE
10100 ORLAND PARKWAY SUITE 110
ORLAND PARK, ILLINOIS 60467
(708) 799-4400
WWW.LINDENGROUPINC.COM



14 W 361 S. Frontage Rd., Suite 106
Burr Ridge, IL 60527
(630) 734-0883

GoodVets
Proposed Animal Hospital
5088 West Atlantic Ave.
Delray Beach, FL 33484

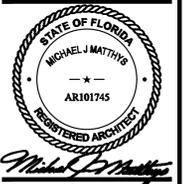

DATE: 12-15-2021
DRAWN: MAS
DESCRIPTION: ISSUE FOR PERMIT

PROJECT NUMBER: 2021-0199
DATE: 12-15-2021

DRAWN BY: MS
FINAL REVIEW: MM

COPYRIGHT - LINDEN GROUP INC. ALL RIGHTS RESERVED.
ALL DRAWINGS, SPECIFICATIONS, SCHEDULES, CONCEPTS, MEMORANDUMS AND RECORDS REPRESENTED OR REFERRED TO IN THESE DOCUMENTS ARE THE PROPERTY OF LINDEN GROUP INC. NOISE OF THE ABOVE WILL BE DELETED TO ANY EXTENT FOR ANY REASON, WITHOUT THE EXPRESS WRITTEN AUTHORIZATION OF LINDEN GROUP INC.

SHEET TITLE: FLOOR PLAN

SHEET NUMBER

A-1.0

P:\2021\2021-0199\Drawing Title\Contractor Documents\Architectural\2021-0199_A-1.0_Floor_Plan.dwg, 12/15/2021 5:35 PM, MSP/M2021A, A-1.0