

Construction Notes: (Customer installing conduit and handoles)

Customer to install 2" conduit and 17" HH and 24" HH. Call Locates before digging for each location

Loc. 1-85: FPL contractor to install (85) GREEN WASHINGTON FOR SINGLE POST TOPS 18' 6" (14' 6" MH) POLE and (85)HOLOPHANE GRANVILLE GREEN/GREEN 39W 3000K 5,190L.

Verify fixture is working correctly after installation.


Check 120V to terminal blocks.

'CHECK VOLTAGE – CONVERT 480V to 120V or 240V' On 480V circuits, change the relay prior to installing the lights. Verify the source and amount of lights on that relay. Contact the FPL PL to assist with this process.

- -All locations are 17"HH unless otherwise specified.
- -FPL crew to run #6 DPX UG cable to all locations shown in the drawing.
- -All facilities to be installed within utility easement.
- -Customer to contact FPL PL and coordinate staking of all locations prior LED installations. Customer is responsible for any restoration required.

FPL LED Representative: Gladys Reyes

	AS-BUILT CRE	W PRIN	NT .		ILL REQUIRED GROUND RODS HA				JOB CERTIFIED COMPLETED AS		UILT	AS-B	UILT COPY
				BE	WITH IN FPLSTAN DARDS, VALUE	SARE SHOWN AT ALL LOCA	ATI ON S.		PRINT. MATERI AL CHAN	SESS HO WIN ON KOS			
FOR	EM AN' S S IGN AT URE		DATE	FO REM AN' S S IGN AT U	RE	-	DATE	SUPERVI	SO IT S S IGN AT URE	DATE		INITIALS	CERT. D ATE
Ease	nent? Yes 🛛 No 🛭] [Survey/Stake?	Yes 🛛 No 🗌	Work with SMO?	Yes No X	FPL						
Tree	Work? Yes ☐ No	X	Designer/Stak	e? Yes No 🛚	CT/Special Mtr?	Yes No X		Ci	ity of Delray	- Along	Barwick	Rd	
PERMIT	City	Cour	nty Rd.	County Air	State Road	FAA	Inst	all 85	5 Green Hold	phane	Post and	85 Pc	les
REQ'D	WMD	RR X	ing	DR. Dist.	Transm.								
	uested Tel. Co. Set Pole quested Tel. Co. Transfe		YES N) (4)	ele. Attachment Per		Designed by:		Jesufane Mento	or Da	te:	12/20	/22
	quest CAVT Transfer?		YES NO	=	Felephone Co.Job No.		Drawn by:	JJM	Check by:	Dv	vg No.	10	F 11
PO	LE LINE FEET		0'	DUCT BANK FT.	() '	Rural Locatio	n Sec.	09 TW	P. 28	S, RGE	. 37	E.
Р	OLE LINEFT. ON TRANS	M. POLI	es 0'	TREN CH FT.	0'	·	SCALE:	N.T.S	St. Lt MAP N	lo. MAP#	Pri Map	No.	CC0709
TLN	1/LDS MODEL No.	-	Map Po	sting? YES X	NO Poste	d by:	WR XXXXX	XXX				M/A	BV

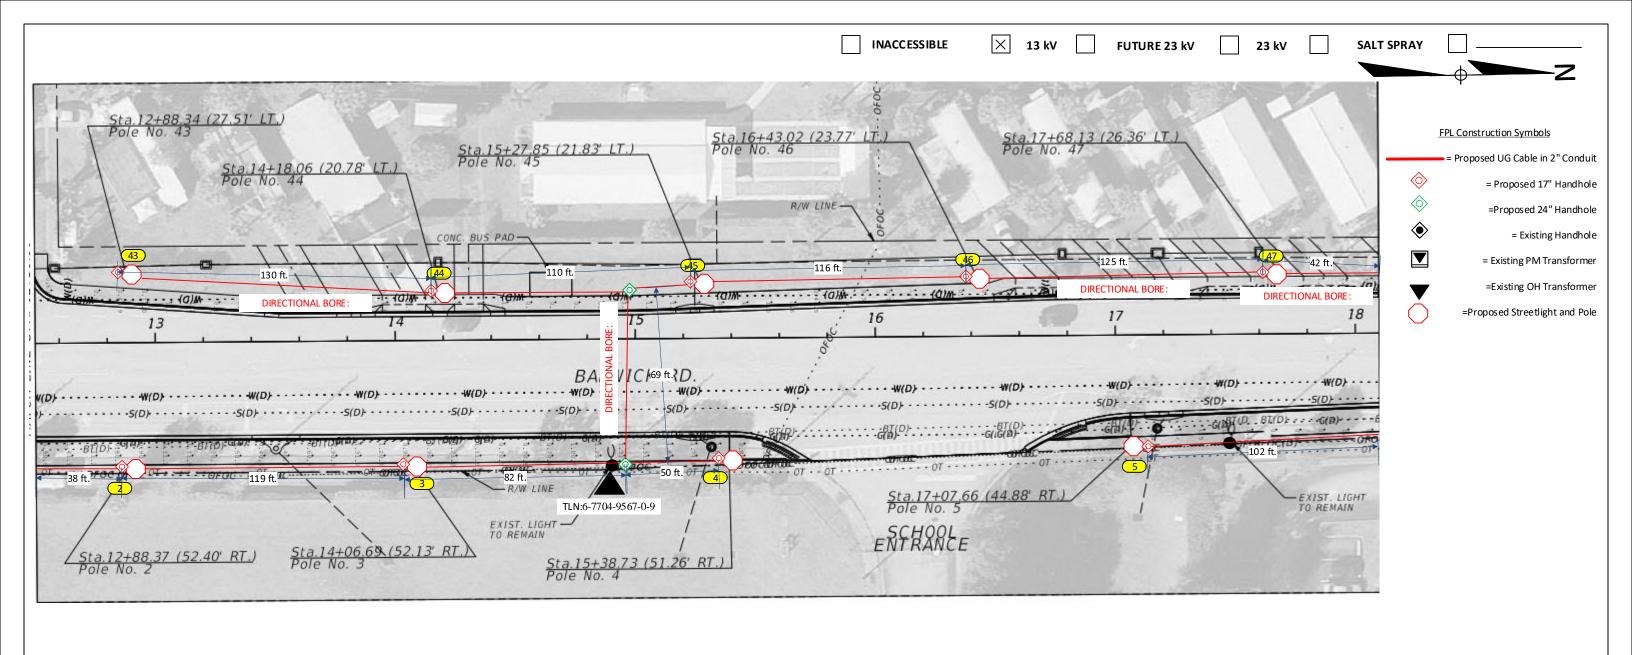

Construction Notes: (Customer installing conduit and handoles)

Customer to install 2" conduit and 17" HH and 24" HH. Call Locates before digging for each location


Loc. 1-85: FPL contractor to install (85) GREEN WASHINGTON FOR SINGLE POST TOPS 18' 6" (14' 6" MH) POLE and (85)HOLOPHANE GRANVILLE GREEN/GREEN 39W 3000K 5,190L.

Verify fixture is working correctly after installation.

Check 120V to terminal blocks.

- -All locations are 17"HH unless otherwise specified.
- -FPL crew to run #6 DPX UG cable to all locations shown in the drawing.
- -All facilities to be installed within utility easement.
- -Customer to contact FPL PL and coordinate staking of all locations prior LED installations. Customer is responsible for any restoration required.
- FPL LED Representative: Gladys Reyes

	AS-BUILT CR	EW PRINT	•		LL REQUIRED GROUND RODS HA				JOB		IPLETED AS SHOW RIAL CHANGESS		BUILT		AS-BUIL	т сору
					,,,,,,											
FO REM	AN' S S IGN AT URE		DATE	FO REM AN' S S IGN AT U	RE	-	DATE	SU P	ERVI SO R'S S IG	N AT URE		DATE		INITIA	LS	CERT. D ATE
Easeme	ent? Yes X No		Survey/Stake?	Yes 🔀 No 🗆	Work with SMO?	Yes No X	FPL									
Tree W	ork? Yes No	x	Designer/Stak	e? Yes No 🛚	CT/Special Mtr?	Yes No X	11.		City	of Del	ray- A	long	Barwio	k Rd		
PERMIT	City	Coun	ty Rd.	County Air	State Road	FAA	Ins	tall	85 G	reen l	Holop	hane	Post a	nd 85	Pole	es :
REQ'D	WMD	RR Xir	ng	DR. Dist.	Transm.											
	ested Tel. Co. Set Pole		· = · · ·) <u>M</u>	ele. Attachment Per		Designed by	/ :	Jesu	ıfane N	1entor	Da	ate:	12	2/20/2	2
	iested Tel. Co. Transfe iest CAVT Transfer?	rr YE	· = ···	a ——	elephone Co.Job No.	_	Drawn by:	JJM	l Cl	heck by:		D۱	vg No.		2 OF 1	.1
POLE	LINE FEET	(0'	DUCT BANK FT.	()'	Rural Locati	on Se	c.	09	TWP.	28	S, F	RGE.	37	E.
РО	LE LINEFT. ON TRANS	M. POLES	s 0'	TREN CH FT.	0'		SCALE:	N.T.	S	St. Lt N	MAP No.	MAP#	Pri N	lap No.	C	C0709
TLM/	LDS MODEL No.	-	Map Po	sting? YES X	NO Posted	d by:	WR XXXX	(XXXX						M,	/A	BV
	·-				·-		·									

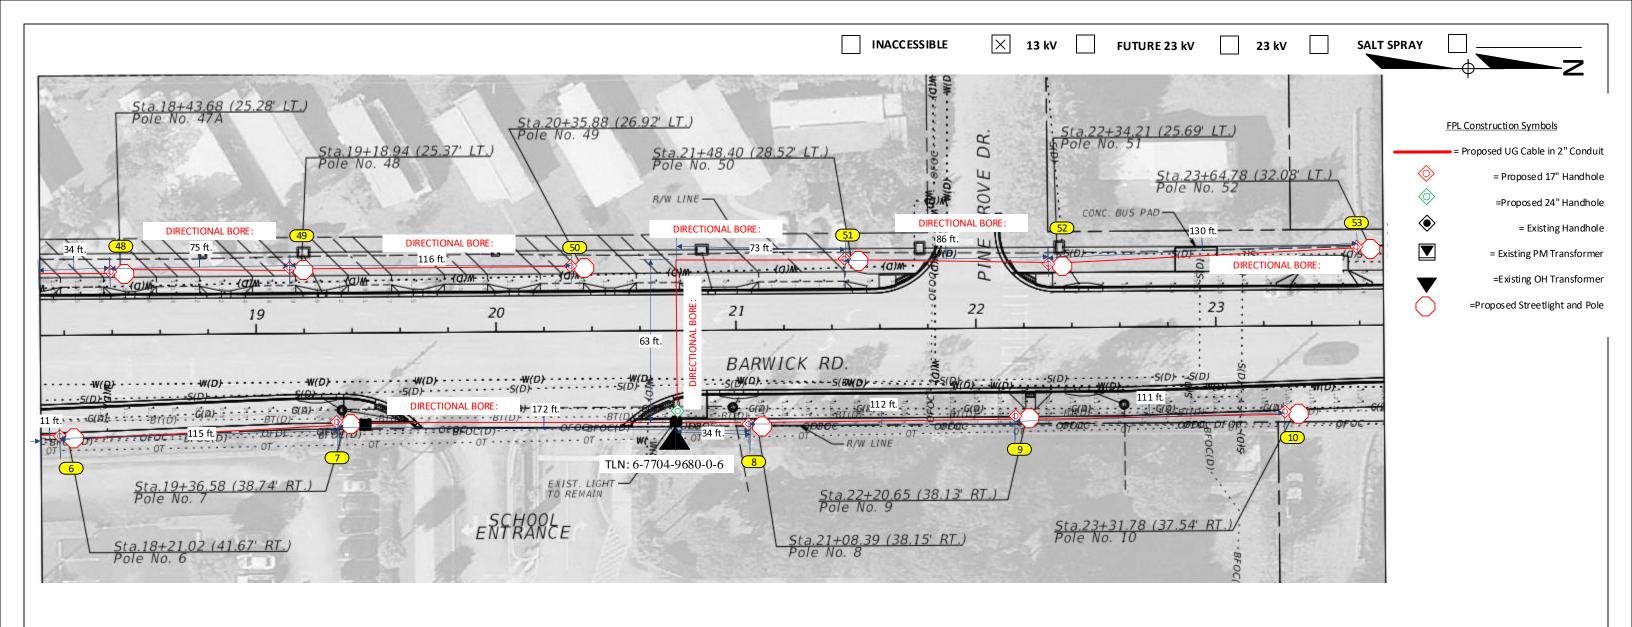

Construction Notes: (Customer installing conduit and handoles)


Customer to install 2" conduit and 17" HH and 24" HH. Call Locates before digging for each location

Loc. 1-85: FPL contractor to install (85) GREEN WASHINGTON FOR SINGLE POST TOPS 18' 6" (14' 6" MH) POLE and (85)HOLOPHANE GRANVILLE GREEN/GREEN 39W 3000K 5,190L.

Verify fixture is working correctly after installation.

- Check 120V to terminal blocks.
- 'CHECK VOLTAGE CONVERT 480V to 120V or 240V' On 480V circuits, change the relay prior to installing the lights. Verify the source and amount of lights on that relay. Contact the FPL PL to assist with this process.
- -All locations are 17"HH unless otherwise specified.
- -FPL crew to run #6 DPX UG cable to all locations shown in the drawing.
- -All facilities to be installed within utility easement.
- -Customer to contact FPL PL and coordinate staking of all locations prior LED installations. Customer is responsible for any restoration required.
- FPL LED Representative: Gladys Reyes

				_										1	
	AS-BUILT CRE	W PRI NT			LL REQUIRED GROUND RODS HA MITH IN FPLSTAN DARDS, VALUE				JOB C		IPLETED AS SHOW RIAL CHANGESSH		ILT	AS	-BUILT COPY
FORE	1 AN' SSIGN AT URE		DATE	FO REM AN' S S IGN AT UP	RE .	-	DATE	SUPE	ERVI SO R S S IGN	ATURE		DATE		INITIALS	CERT. D ATE
Easem	ent? Yes X No		Survey/Stake?	Yes 🔀 No 🗆	Work with SMO?	Yes No X	FPL								
Tree W	/ ork? Yes ☐ No	X	Designer/Stake	Yes No X	CT/Special Mtr?	Yes No 🛚	11.	(City o	f Del	ray- A	long [3arwick	Rd Rd	
PERM IT	City	Count	y Rd.	County Air	FAA	Inst	all 8	85 Gr	een l	Holoph	hane I	ost an	d 85 P	oles	
REQ'D	WMD	RR Xing	g	DR. Dist.	Transm.										
	uested Tel. Co. Set Pole		= '''	Х Х	le. Attachment Per		Designed by:		Jesu	fane N	1entor	Da	te:	12/2	0/22
	uested Tel. Co. Transfer uest CAVT Transfer?	r YES	= '		elephane Co.Job No.	<u> </u>	Drawn by:	JJM	l Ch	eck by:		Dw	g No.	3	OF 11
POL	E LINE FEET	0)'	DUCT BANK FT.	() '	Rural Location	n Sed	c.	09	TWP.	28	S, RG	iE. 3	7 E.
PC	LE LINEFT. ON TRANSI	M. POLES	0'	TREN CH FT.	0'		SCALE:	N.T.S	.S	St. Lt N	MAP No.	MAP#	Pri Ma	p No.	CC0709
TLM	/LDS MODEL No.	-	Map Pos	ting? YES 🔀	NO Posted	d by:	WR XXXXX	XXX						M/A	BV

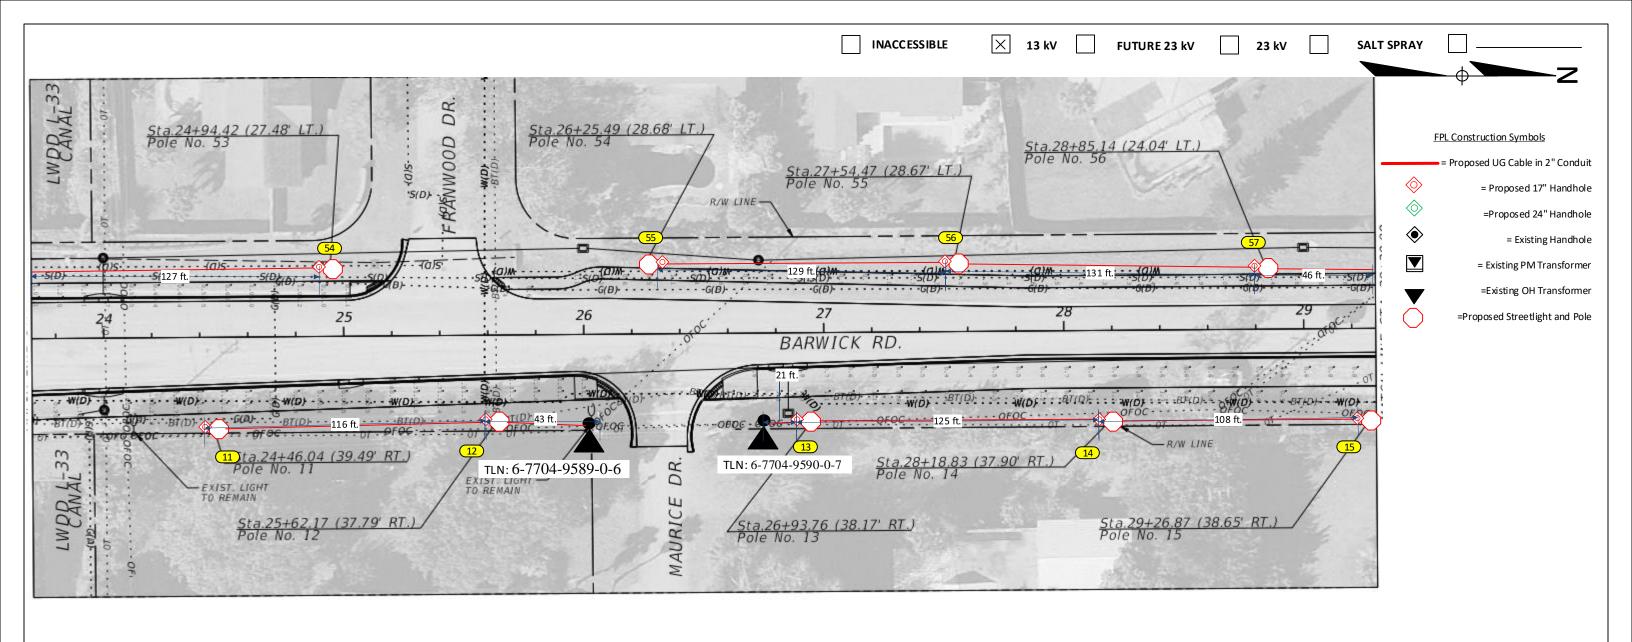

Construction Notes: (Customer installing conduit and handoles)

Customer to install 2" conduit and 17" HH and 24" HH. Call Locates before digging for each location

Loc. 1-85: FPL contractor to install (85) GREEN WASHINGTON FOR SINGLE POST TOPS 18' 6" (14' 6" MH) POLE and (85)HOLOPHANE GRANVILLE GREEN/GREEN 39W 3000K 5,190L.

Verify fixture is working correctly after installation.


Check 120V to terminal blocks.

'CHECK VOLTAGE – CONVERT 480V to 120V or 240V' On 480V circuits, change the relay prior to installing the lights. Verify the source and amount of lights on that relay. Contact the FPL PL to assist with this process.

- -All locations are 17"HH unless otherwise specified.
- -FPL crew to run #6 DPX UG cable to all locations shown in the drawing.
- -All facilities to be installed within utility easement.
- -Customer to contact FPL PL and coordinate staking of all locations prior LED installations. Customer is responsible for any restoration required.

FPL LED Representative: Gladys Reyes

	AS-BUILT CR	EW PRINT	1		ALL REQUIRED GROUND RODS HA				10		MPLETED AS SHOW RIAL CHANGESS F				AS-BU	ILT COPY	
					,												
						_								_ _			
FO REM	1 AN' S S IGN AT URE		DATE	FO REM AN' S S IGN AT U	RE		DATE		SU PERVISO R'SSI	GN AT URE		DA:	re	INI	TIALS	CERT. DA	.TE
Easem	ent? Yes 🛛 No		Survey/Stake?	Yes 🛛 No 🗌	Work with SMO?	Yes No X	FPL										
Tree W	ork? Yes No	X	Designer/Stak	e? Yes No 🛚	CT/Special Mtr?	Yes No X			City	of Del	Iray- A	long	Barv	ick Ro	ł		
PERMIT	City	Coun	ty Rd.	County Air	State Road	FAA	In	sta	II 85 G	reen l	Holop	hane	Post	and 8	5 Po	es	
REQ'D	WMD	RR Xin	ng	DR. Dist.	Transm.												
	uested Tel. Co. Set Pole uested Tel. Co. Transfe		=) <u>M</u>	ele. Attachment Per		Designed b	y:	Jes	ufane N	/lentor		ate:		12/20/	22	
•	uest CAVT Transfer?	YE	_ =	_	Telephone Co. Job No.	_	Drawn by:	J.	JM C	heck by:		0	wg No.		4 OF	11	
POL	E LINE FEET	()'	DUCT BANK FT.	()'	Rural Locat	tion	Sec.	09	TWP.	2	8 S,	RGE.	37	E.	
РО	LE LINEFT. ON TRANS	M. POLES	0'	TREN CH FT.	0'		SCALE:	N	l.T.S	St. Lt f	MAP No.	MAP	# Pri	Map N	0.	CC0709	,
TLM	LDS MODEL No.	-	Map Po	sting? YES	NO Posted	d by:	WR XXX	XXX	XX					N	Л/A	BV	
				<u> </u>	·-												

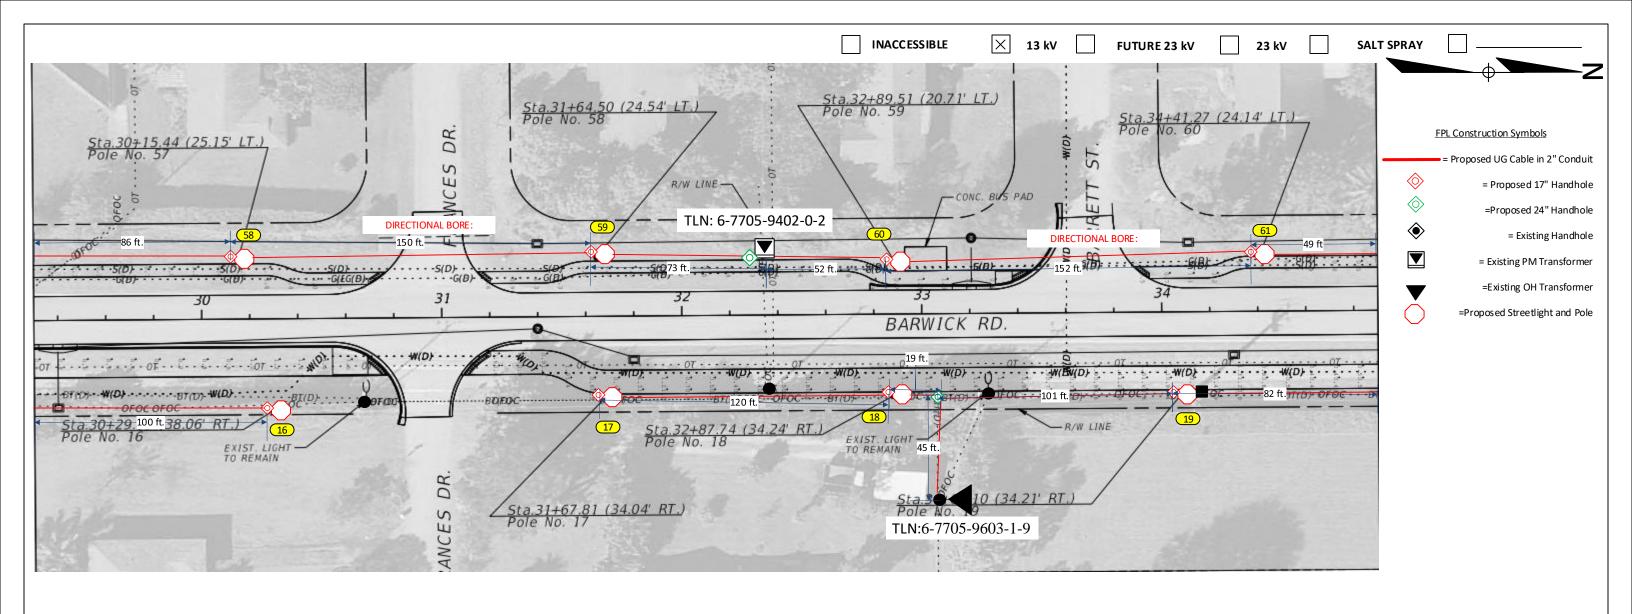

Construction Notes: (Customer installing conduit and handoles)

Customer to install 2" conduit and 17" HH and 24" HH. Call Locates before digging for each location


Loc. 1-85: FPL contractor to install (85) GREEN WASHINGTON FOR SINGLE POST TOPS 18' 6" (14' 6" MH) POLE and (85)HOLOPHANE GRANVILLE GREEN/GREEN 39W 3000K 5,190L.

Verify fixture is working correctly after installation.

Check 120V to terminal blocks.

- -All locations are 17"HH unless otherwise specified.
- -FPL crew to run #6 DPX UG cable to all locations shown in the drawing.
- -All facilities to be installed within utility easement.
- -Customer to contact FPL PL and coordinate staking of all locations prior LED installations. Customer is responsible for any restoration required.
- FPL LED Representative: Gladys Reyes

AS-BUILT CREW PRINT ALL REQUIRED GROUND RODS HAVE BEEN DRIVEN & VERFECT OR DRIVEN & VERFECT OR DRIVEN A V	
FOREMAN'S SIGNATURE DATE FOREMAN'S SIGNATURE DATE NITIALS CERT Easement? Yes \(\overline{\text{N}}\) No \(\overline{\text{N}}\) Survey/Stake? Yes \(\overline{\text{N}}\) No \(\overline{\text{N}}\) No \(\overline{\text{N}}\) Designer/Stake? Yes \(\overline{\text{N}}\) No \(\overline{\text{N}}\) No \(\overline{\text{N}}\) Tree Work? Yes \(\overline{\text{N}}\) No \(\overline{\text{N}}\) Designer/Stake? Yes \(\overline{\text{N}}\) No \(\overline{\text{N}}\) Yes \(\overline{\text{N}}\) No \(\overline{\text{N}}\) City of Delray- Along Barwick Rd	Ý
Easement? Yes No Designer/Stake?	
Easement? Yes No Designer/Stake?	
TreeWork? Yes□No☑ Designer/Stake? Yes□No☑ CT/Special Mtr? Yes□No☑ City of Delray- Along Barwick Rd	. D ATE
Tree Work? Yes No X Designer/Stake? Yes No X CT/Special Mtr? Yes No X City of Delray- Along Barwick Rd	
City County Rd County Air State Road FAA Install 85 Green Holonhane Post and 85 Poles	
This can be direct the bound of the same need of the same	
RR Xing DR. Dist. Transm.	
Requested Tel. Co. Set Poles? YES NO NO Tele. Attachment Per Requested Tel. Co. Transfer? YES NO	
Request CAVTTransfer? YES NO X Telephone Co. Job No. No X	
POLE LINE FEET 0' DUCT BANK FT. 0' Rural Location Sec. 09 TWP. 28 S, RGE. 37 E	
POLE LINE FT. ON TRANSM. POLES 0' TRENCH FT. 0' SCALE: N.T.S St. Lt MAP No. MAP# Pri Map No. CC07)9
TLM/LDS MODEL No Map Posting? YES 🔀 NO 🗌 Posted by: WR XXXXXXXXX M/A B	V

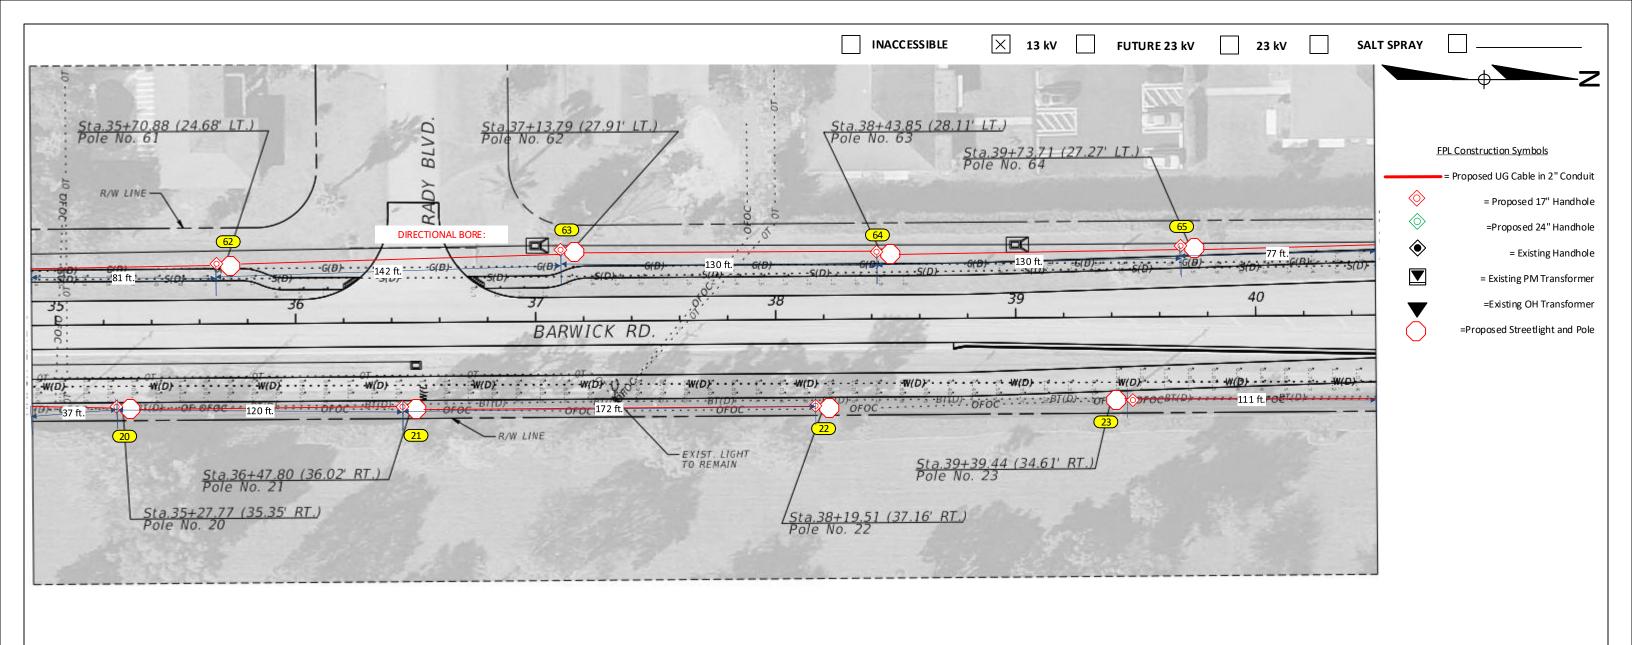

Construction Notes: (Customer installing conduit and handoles)

Customer to install 2" conduit and 17" HH and 24" HH. Call Locates before digging for each location


Loc. 1-85: FPL contractor to install (85) GREEN WASHINGTON FOR SINGLE POST TOPS 18' 6" (14' 6" MH) POLE and (85)HOLOPHANE GRANVILLE GREEN/GREEN 39W 3000K 5,190L.

Verify fixture is working correctly after installation.

Check 120V to terminal blocks.

- -All locations are 17"HH unless otherwise specified.
- -FPL crew to run #6 DPX UG cable to all locations shown in the drawing.
- -All facilities to be installed within utility easement.
- -Customer to contact FPL PL and coordinate staking of all locations prior LED installations. Customer is responsible for any restoration required.
- FPL LED Representative: Gladys Reyes

	AS-BUILT CRI	EW PRINT			LL REQUIRED GROUND RODS HA				10		MPLETED AS SHOW RIAL CHANGESS F		BUILT		AS-BI	JILT COP	Y
					,												
				-		-								_ _			
FO REM	A AN' S S IGN AT URE		DATE	FO REM AN' S S IGN AT U	RE		DATE		SU PERVISO R'S S K	IN AT URE		DAT	E	IN	IT IAL S	CERT	T.DATE
Easem	nent? Yes 🛛 No		Survey/Stake?	Yes 🛛 No 🗌	Work with SMO?	Yes No X	FPL										
Tree W	/ork? Yes No	X	Designer/Stak	e? Yes No X	CT/Special Mtr?	Yes No X			City	of De	Iray- A	long	Barw	ick R	b		
PERMIT	City	Count	y Rd.	County Air	State Road	FAA	Ins	sta	II 85 G	reen l	Holop	hane	Post	and 8	5 Po	les	
REQ'D	WMD	RR Xin	g	DR. Dist.	Transm.												
	uested Tel. Co. Set Pole uested Tel. Co. Transfe		=) <u>IA</u>	le. Attachment Per		Designed b	y:	Jes	ufane N	/lentor	D	ate:		12/20,	/22	
•	uest CAVT Transfer?	YES	= ``		elephane Co.Job No.	_	Drawn by:	J	JM C	heck by:		D	wg No.		6 OI	11	
POL	E LINE FEET	0) ¹	DUCT BANK FT.	()'	Rural Locat	ion	Sec.	09	TWP.	28	3 S,	RGE.	37	E.	
РО	LE LINEFT. ON TRANS	M. POLES	0'	TREN CH FT.	0'		SCALE:	N	I.T.S	St. Lt I	MAP No.	MAP#	‡ Pri	Map N	0.	CC070	09
TLM	/LDS MODEL No.	-	Map Po	sting? YES 🔀	NO Posteo	d by:	WR XXX	XXX	XX					1	И/A	В	V

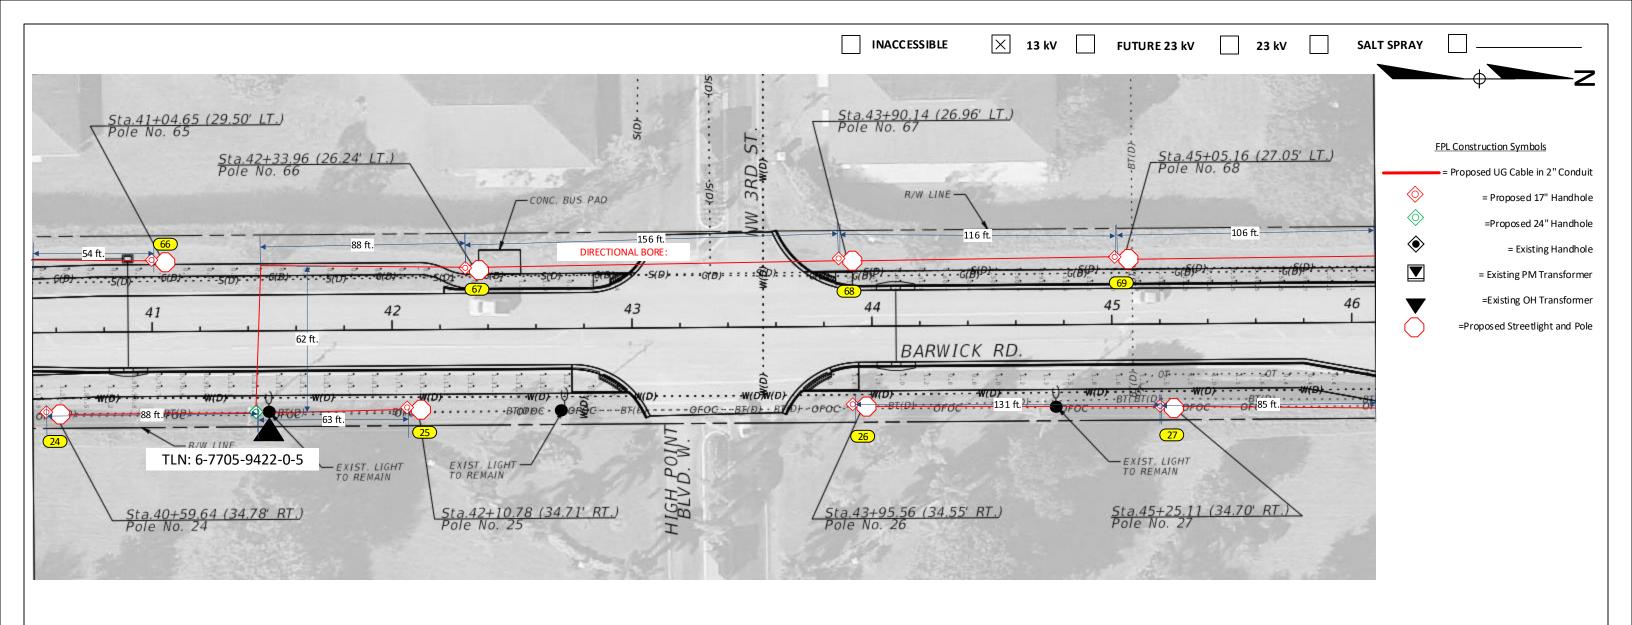

Construction Notes: (Customer installing conduit and handoles)

Customer to install 2" conduit and 17" HH and 24" HH. Call Locates before digging for each location


Loc. 1-85: FPL contractor to install (85) GREEN WASHINGTON FOR SINGLE POST TOPS 18' 6" (14' 6" MH) POLE and (85)HOLOPHANE GRANVILLE GREEN/GREEN 39W 3000K 5,190L.

Verify fixture is working correctly after installation.

Check 120V to terminal blocks.

- -All locations are 17"HH unless otherwise specified.
- -FPL crew to run #6 DPX UG cable to all locations shown in the drawing.
- -All facilities to be installed within utility easement.
- -Customer to contact FPL PL and coordinate staking of all locations prior LED installations. Customer is responsible for any restoration required.
- FPL LED Representative: Gladys Reyes

	AS-BUILT CRI	W PRI NT	7		LL REQUIRED GROUND RODS HA				JOE		MPLETED AS SHOW RIAL CHANGES SH				AS-BUIL	ГСОРУ
				52	III III II ES IAIGSANDS, VA EGE	JAKE SHOWN AT ALEEO C										
						_		_								
FO REM	A AN' S S IGN AT URE		DATE	FO REM AN' S S IGN AT U	RE		DATE	SL	J PERVI SOR S S IG	N AT URE		DAT	E	INITU	AL S	CERT. D ATE
Easem	nent? Yes X No		Survey/Stake?	Yes 🛛 No 🗌	Work with SMO?	Yes No X	FPL									
Tree W	/ork? Yes No	X	Designer/Stak	e? Yes No X	CT/Special Mtr?	Yes No X			City	of Del	lray- A	long	Barwio	ck Rd		
PERMIT	City	Coun	ty Rd.	County Air	State Road	FAA	Ins	tall	85 G	reen l	Holopl	hane	Post a	nd 85	Pole	S
REQ'D	WMD	RR Xir	ng	DR. Dist.	Transm.											
	uested Tel. Co. Set Pole uested Tel. Co. Transfe		=) (4)	ele. Attachment Per		Designed by	<i>r</i> :	Jesu	ufane N	/lentor	D	ate:	1	2/20/2	2
•	uest CAVT Transfer?	YE YE	_ =		elephone Co. Job No.	<u> </u>	Drawn by:	JJN	√l Cl	heck by:		D	wg No.		7 OF 1	1
POL	E LINE FEET	()'	DUCT BANK FT.	()'	Rural Locatio	on S	ec.	09	TWP.	28	3 S, F	RGE.	37	E.
РО	LE LINEFT. ON TRANS	M. POLES	0'	TREN CH FT.	0'		SCALE:	N.T	Γ.S	St. Lt N	MAP No.	MAP#	# Pri N	1ap No	. С	C0709
TLM	/LDS MODEL No.	-	Map Po	sting? YES X	NO Posted	d by:	WR XXXX	(XXX	Χ					М	/A	BV
,	, 220 11102221101		IVIAPIO	string: ILS LA	10 103100		VVII /OUT/	VVV	^					171	,,,	DV

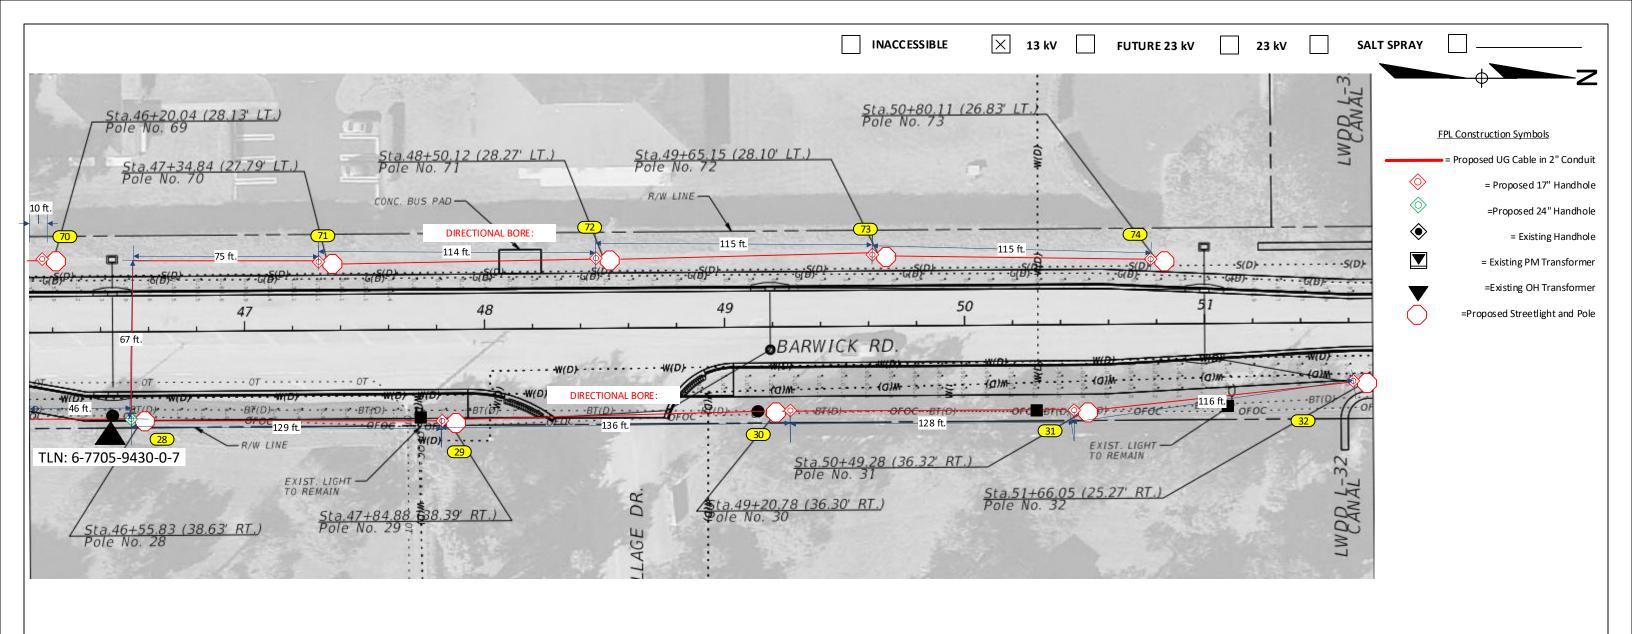

Construction Notes: (Customer installing conduit and handoles)

Customer to install 2" conduit and 17" HH and 24" HH. Call Locates before digging for each location


Loc. 1-85: FPL contractor to install (85) GREEN WASHINGTON FOR SINGLE POST TOPS 18' 6" (14' 6" MH) POLE and (85)HOLOPHANE GRANVILLE GREEN/GREEN 39W 3000K 5,190L.

Verify fixture is working correctly after installation.

Check 120V to terminal blocks.

- -All locations are 17"HH unless otherwise specified.
- -FPL crew to run #6 DPX UG cable to all locations shown in the drawing.
- -All facilities to be installed within utility easement.
- -Customer to contact FPL PL and coordinate staking of all locations prior LED installations. Customer is responsible for any restoration required.
- FPL LED Representative: Gladys Reyes

	AS-BUILT CRI	EW PRINT			LL REQUIRED GROUND RODS HA				J		MPLETED AS SHOW ERIAL CHANGES SH		BUILT		AS-BUI	LT COPY
					III III II ES IAI BAILBS, VA ESC	JAKE SHOWN AT ALEEO C										
						_								_		
FO REM	A AN' S S IGN AT URE		DATE	FO REM AN' S S IGN AT U	RE		DATE		SU PERVI SO R'S S	IGN AT URE		DAT		IN IT	IALS	CERT. D ATE
Easem	nent? Yes X No		Survey/Stake?	Yes 🛛 No 🗌	Work with SMO?	Yes No X	FPL									
Tree W	/ork? Yes No	X	Designer/Stake	? Yes No X	CT/Special Mtr?	Yes No X			City	of De	Iray- A	long	Barw	ick Rd		
PERMIT	City	Count	ty Rd.	County Air	State Road	FAA	In	sta	all 85 G	ireen	Holoph	hane	Post	and 8	5 Pol	es
REQ'D	WMD	RR Xin	ng	DR. Dist.	Transm.											
	uested Tel. Co. Set Pole uested Tel. Co. Transfe		=) <u>LA</u>	le. Attachment Per		Designed b	y:	Je:	sufane N	∕lentor	D	ate:	1	2/20/2	22
	uest CAVT Transfer?	YE YE	· = · · ·	_	elephane Co.Job No.	_	Drawn by:	J	IJM (Check by		D	wg No.		8 OF	11
POL	E LINE FEET	C)'	DUCT BANK FT.	()'	Rural Locat	tion	Sec.	09	TWP.	28	S S,	RGE.	37	E.
PC	LE LINEFT. ON TRANS	M. POLES	0'	TREN CH FT.	0'		SCALE:	Ν	I.T.S	St. Lt	MAP No.	MAP#	Pri	Map No). (CC0709
TLM	/LDS MODEL No.	-	Map Po	sting? YES 🔀	NO Posteo	d by:	WR XXX	XXX	ΧX					Ν	1/A	BV

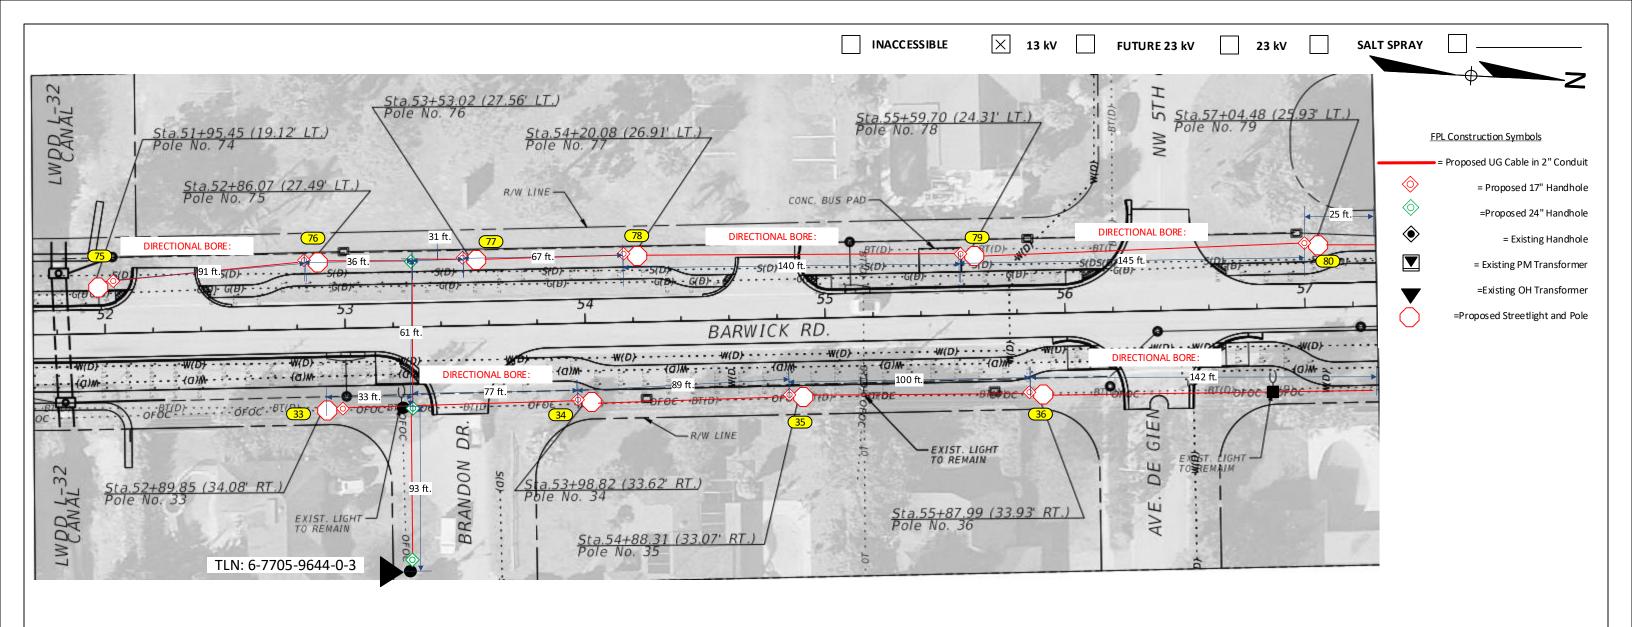

Construction Notes: (Customer installing conduit and handoles)

Customer to install 2" conduit and 17" HH and 24" HH. Call Locates before digging for each location


Loc. 1-85: FPL contractor to install (85) GREEN WASHINGTON FOR SINGLE POST TOPS 18' 6" (14' 6" MH) POLE and (85)HOLOPHANE GRANVILLE GREEN/GREEN 39W 3000K 5,190L.

Verify fixture is working correctly after installation.

Check 120V to terminal blocks.

- -All locations are 17"HH unless otherwise specified.
- -FPL crew to run #6 DPX UG cable to all locations shown in the drawing.
- -All facilities to be installed within utility easement.
- -Customer to contact FPL PL and coordinate staking of all locations prior LED installations. Customer is responsible for any restoration required.
- FPL LED Representative: Gladys Reyes

	AS-BUILT CR	EW PRI	NT		LL REQUIRED G ROUND RODS HA WITH IN FPLSTAN DARDS, VALUE						MPLETED AS SHOW ERIAL CHANGESSI	NON THIS A S-BUIL HOWN ON ROS	LT	AS-E	UILT COPY
FORE	M AN' S S IGN AT URE		DATE	FO REM AN' S S IGN AT U	RE	-	DATE	-	SU PERVISO R'S	S IGN AT URE		DATE		IN IT IAL S	CERT. D ATE
Easen	nent? Yes 🛛 No		Survey/Stake?	Yes 🛛 No 🗌	Work with SMO?	Yes No X	FPL								
Tree V	Vork? Yes ☐ No	X	Designer/Stak	e? Yes No X	CT/Special Mtr?	Yes No X			City	of De	Iray- A	long B	arwick F	₹d	
PERM IT	City	Cou	nty Rd.	County Air	State Road	FAA	lı	nsta	all 85 (Green	Holop	hane P	ost and	85 Pc	les
REQ'D	WMD	RR X	ing	DR. Dist.	Transm.										
1 .	uested Tel. Co. Set Pole		YES N) <u>LAU</u>	ele. Attachment Per		Designed	by:	Je	sufane N	/lentor	Dat	e:	12/20	/22
	uested Tel. Co. Transfe uest CAVT Transfer?		YES NO	=	elephone Co. Job No.	_	Drawn by:	,	JJM	Check by:		Dw	g No.	9 O	F 11
POI	E LINE FEET		0'	DUCT BANK FT.	()'	Rural Loca	ation	Sec.	09	TWP.	28	S, RGE.	37	E.
PC	DLE LINEFT. ON TRANS	M. POL	es 0'	TREN CH FT.	0'		SCALE:	١	N.T.S	St. Lt	MAP No.	MAP#	Pri Map	No.	CC0709
TLM	/LDS MODEL No.	-	Map Po	sting? YES X	NO Posted	l by:	WR XX	XXXX	ΚΧΧ				·	M/A	BV

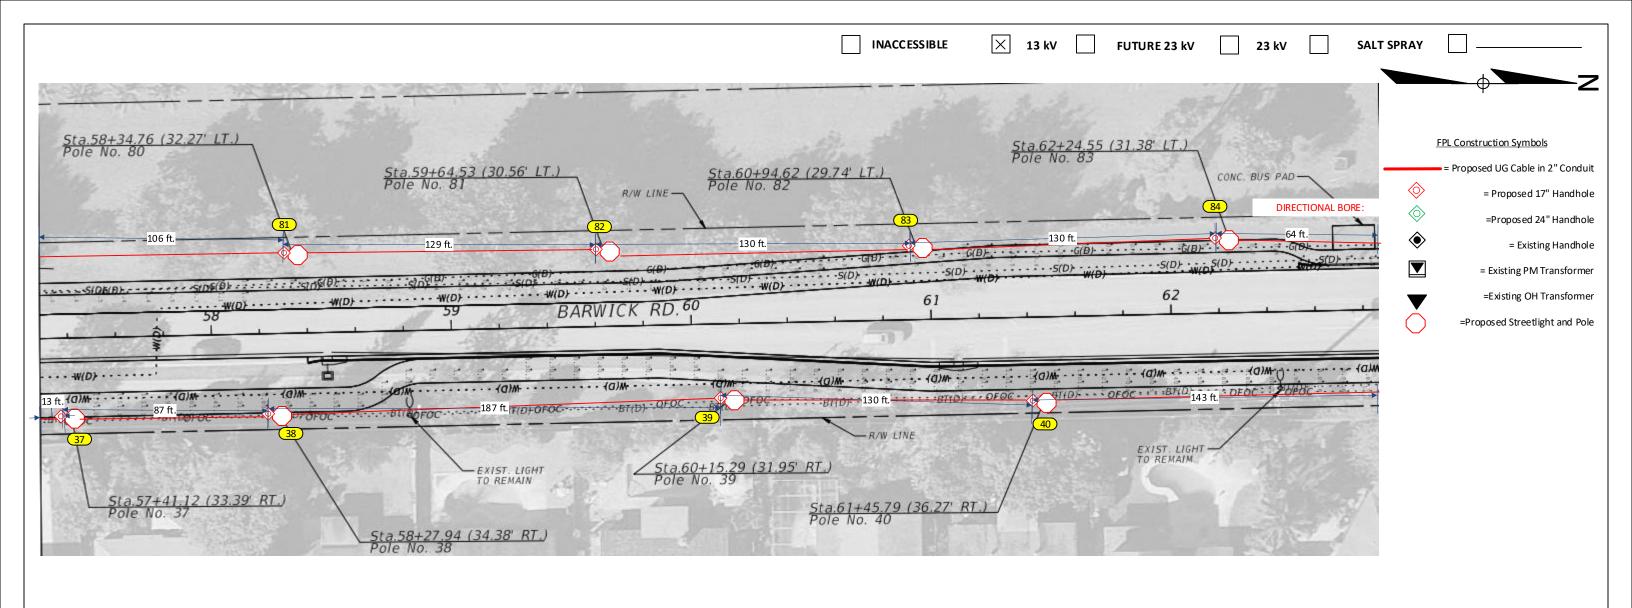

Construction Notes: (Customer installing conduit and handoles)

Customer to install 2" conduit and 17" HH and 24" HH. Call Locates before digging for each location

Loc. 1-85: FPL contractor to install (85) GREEN WASHINGTON FOR SINGLE POST TOPS 18' 6" (14' 6" MH) POLE and (85)HOLOPHANE GRANVILLE GREEN/GREEN 39W 3000K 5,190L.

Verify fixture is working correctly after installation.

Check 120V to terminal blocks.

- -All locations are 17"HH unless otherwise specified.
- -FPL crew to run #6 DPX UG cable to all locations shown in the drawing.
- -All facilities to be installed within utility easement.
- -Customer to contact FPL PL and coordinate staking of all locations prior LED installations. Customer is responsible for any restoration required.
- FPL LED Representative: Gladys Reyes

	AS-BUILT CR	EW PRIN	Т		LL REQUIRED GROUND RODS HA				JOE		IPLETED AS SHOW!		JILT		AS-BU	ILT COPY	
FO REV	1 AN' S S IGN AT URE		DATE	FO REM AN' S S IGN AT U	RE	=	DATE	Si	U PERVI SO R'S S IG	NATURE		DATE		IN IT	ALS	CERT. D ATE	_
Easem	ent? Yes X No		Survey/Stake?	Yes 🔀 No 🗆	Work with SMO?	Yes No X	FPL										
Tree W	ork? Yes□ No	X	Designer/Stake	e? Yes No 🛚	CT/Special Mtr?	Yes No X			City	of Del	ray- A	long	Barwi	ck Rd			
PERMIT	City	Coun	nty Rd.	County Air	State Road	FAA	Ins	tall	85 G	reen l	Holoph	nane	Post a	ind 8	5 Pol	es	
REQ'D	WMD	RR Xi	ng	DR. Dist.	Transm.						-						
	uested Tel. Co. Set Pole uested Tel. Co. Transfe		ES NO) <u>I</u>	ele. Attachment Per		Designed by	y :	Jesu	ufane N	1entor	Da	te:	1	.2/20/	22	
	uest CAVT Transfer?		ES NO		elephane Co. Job No.	_	Drawn by:	JJN	M CI	heck by:		Dw	g No.		10 OF	11	
POL	E LINE FEET		0'	DUCT BANK FT.	C)'	Rural Locati	on S	ec.	09	TWP.	28	S,	RGE.	37	E.	
РО	LE LINEFT. ON TRANS	M. POLE	s 0'	TREN CH FT.	0'		SCALE:	N.T	Γ.S	St. Lt N	ИАР No.	MAP#	Pri N	Лар No).	CC0709	
TLM/	LDS MODEL No.	-	Map Po	sting? YES 🔀	NO Posted	d by:	WR XXXX	XXXX	Х					N	I/A	BV	



Construction Notes: (Customer installing conduit and handoles)

Customer to install 2" conduit and 17" HH and 24" HH. Call Locates before digging for each location

Loc. 1-85: FPL contractor to install (85) GREEN WASHINGTON FOR SINGLE POST TOPS 18' 6" (14' 6" MH) POLE and (85)HOLOPHANE GRANVILLE GREEN/GREEN 39W 3000K 5,190L.

Verify fixture is working correctly after installation.

Check 120V to terminal blocks.

'CHECK VOLTAGE – CONVERT 480V to 120V or 240V' On 480V circuits, change the relay prior to installing the lights. Verify the source and amount of lights on that relay. Contact the FPL PL to assist with this process.

- -All locations are 17"HH unless otherwise specified.
- -FPL crew to run #6 DPX UG cable to all locations shown in the drawing.
- -All facilities to be installed within utility easement.
- -Customer to contact FPL PL and coordinate staking of all locations prior LED installations. Customer is responsible for any restoration required.

FPL LED Representative: Gladys Reyes

	AS-BUILT CR	EW PRINT			LL REQUIRED GROUND RODS HA				100		MPLETED AS SHOW RIAL CHANGES SH		BUILT		AS-BU	ILT COPY	
FOREM	1 AN' S S IGN AT URE		DATE	FO REM AN' S S IGN AT UP	RE	=	DATE	-	SU PERVI SO R'S S IG	GN AT URE		DATE			IALS	CERT. D ATE	-
Easem	ent? Yes X No		Survey/Stake?	Yes 🛛 No 🗌	Work with SMO?	Yes No X	FPL										
Tree W	ork? Yes□ No	X	Designer/Stake	? Yes No 🛚	CT/Special Mtr?	Yes No X			City	of Del	ray- A	long	Barw	ick Ro			
PERMIT	City	Count	y Rd.	County Air	State Road	FAA	Ins	stal	ll 85 G	reen l	Holoph	nane	Post	and 8	5 Pol	es	
REQ'D	WMD	RR Xin	g	DR. Dist.	Transm.						•						
	uested Tel. Co. Set Pole uested Tel. Co. Transfe		= ''') <u>IA</u>	ele. Attachment Per		Designed by	y:	Jes	ufane N	1entor	Da	ite:	:	12/20/	22	
•	uest CAVT Transfer?	YES	=		elephane Co. Job No.	_	Drawn by:	IJ	M C	heck by:		D۱	vg No.		11 OF	11	
POLI	E LINE FEET	0)'	DUCT BANK FT.	C)'	Rural Locati	ion S	Sec.	09	TWP.	28	S,	RGE.	37	E.	
РО	LE LINEFT. ON TRANS	M. POLES	0'	TREN CH FT.	0'		SCALE:	N.	T.S	St. Lt N	MAP No.	MAP#	Pri	Map N).	CC0709	
TLM/	LDS MODEL No.	-	Map Po	sting? YES	NO Posted	d by:	WR XXXX	XXXX	(X					N	1/A	BV	
	•	•	•	•	•				•		•	•		•	•		