




BOUNCE SPORTING CLUB, DELRAY
PRELIMINARY SECURITY PLAN
SUPPORTING DOCUMENTS
2.13.21

PRELIMINARY SECURITY CAMERA PLOT:

SCALE 1/8" = 1'-0"

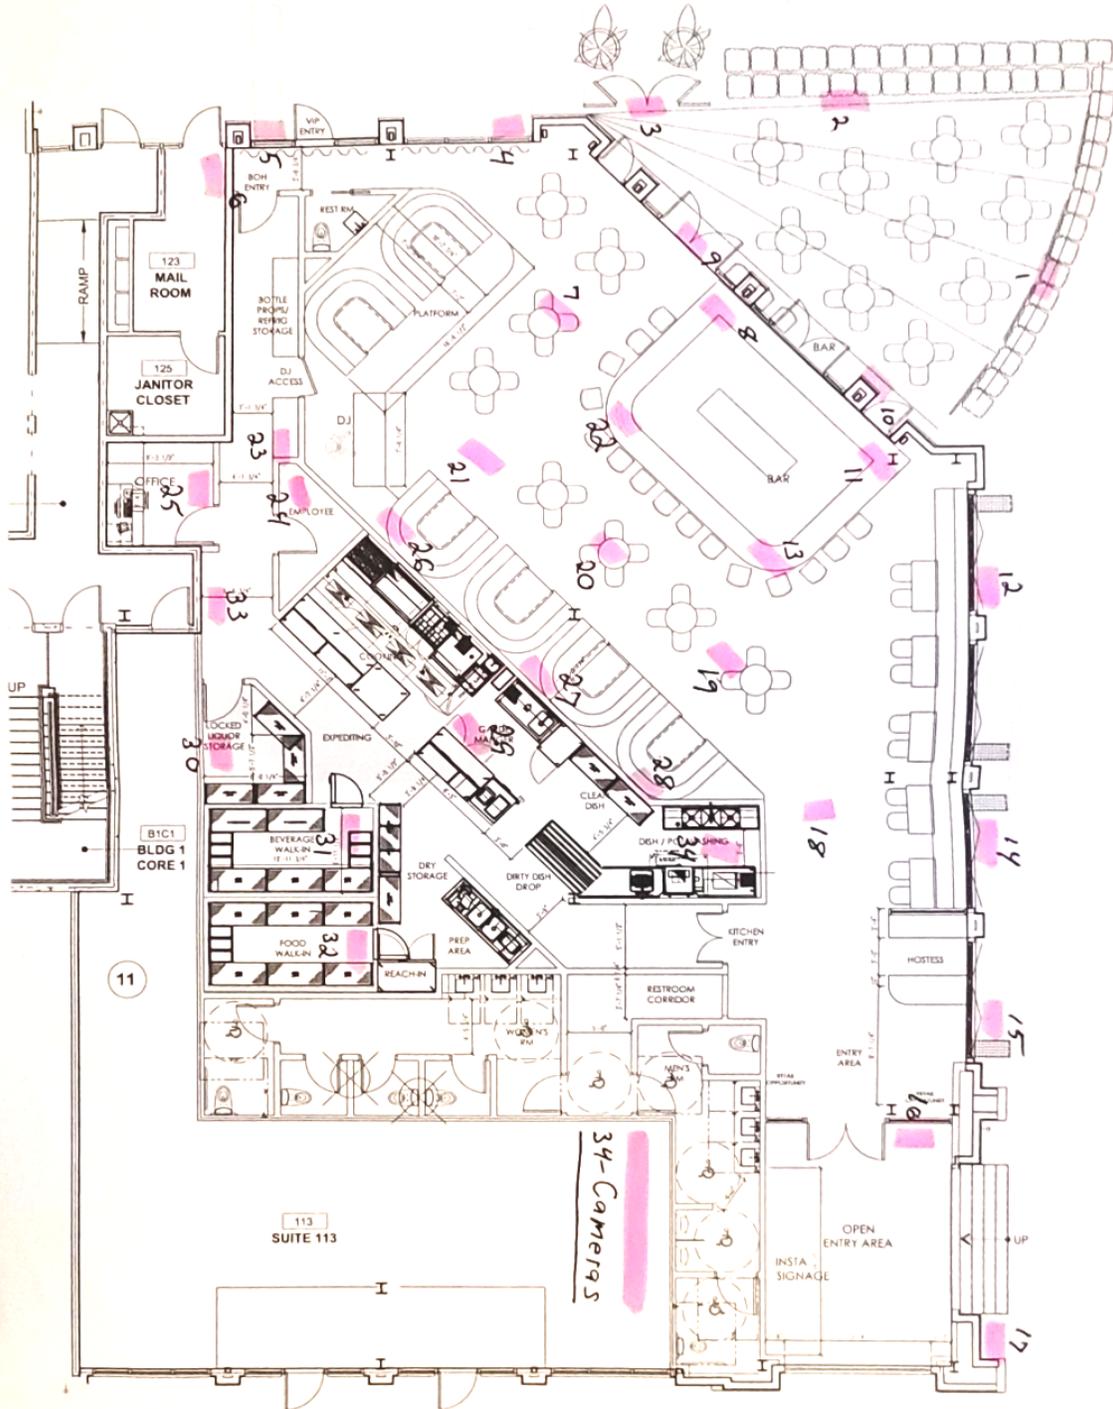

T&T AUDIO VISUAL INC. PRELIMINARY PROPOSAL:



T & T PRODUCTIONS

PROPOSAL

DATE	NUMBER
2/12/2021	5468

T & T Audio Visual Inc

11284 162nd Place N
Jupiter, FL 33478-6106

Name / Address
BOUNCE SPORTING CLUB DELRAY

JOB ADDRESS
BOUNCE SPORTING CLUB DELRAY


Terms	Rep	PROJECT	CUST PHONE
		CAMERAS	
Description	Qty	Cost	Total
CAMERA SYSTEM			
34 HD DIGITAL WATCHDOG 4MP 2.8.MM IP CAMERAS WITH NIGHTVISION	34	225.14	7,654.76T
34 IP licences	34	65.00	2,210.00T
1 DIGITAL WATCHDOG 18TB NVR RECORDING DEVICE WITH SPECTRUM SOFTWARE	1	3,700.00	3,700.00T
1 32" HD 4K MONITOR	1	290.00	290.00T
SWITCHES: WIRE: CONNECTORS:POE: HARDWARE	1	1,450.00	1,450.00T
LABOR 2 MEN@3 DAYS FOR COMPLETE PROGRAMMING AND OPERATION	64	75.00	4,800.00T
NOTE ALL PERMIT FEES EXTRA			
NOTE: ALL EMT OR ELECTRICAL PIPE DONE BY OTHERS			
NOTE: PLEASE ADD SALES TAX			
Wholesale - Vendor with re-sale certificate		0.00%	0.00

Thank you for your business.	Total	\$20,104.76
------------------------------	--------------	-------------

Phone #	E-mail	Fax #
754-222-8530	office@tandtaudiovisual.c...	561-743-1511


Customer Sign... _____

PRELIMINARY EXTERIOR SECURITY LIGHT PLOT:

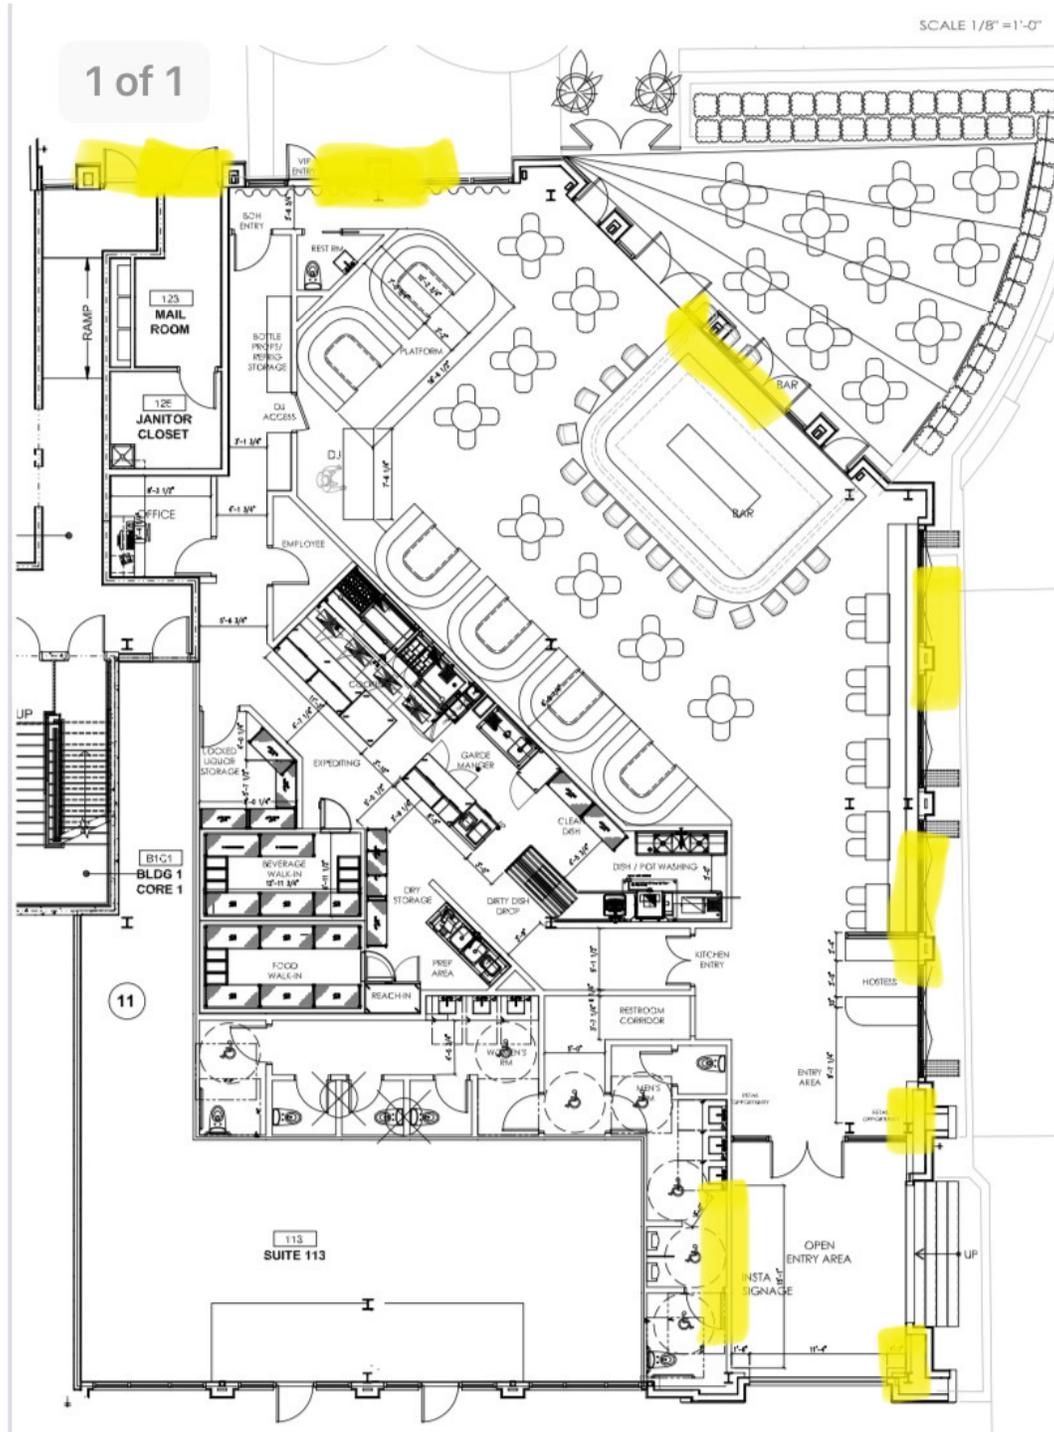

- after- hours motion-sensored lights will be installed within the Interior of the venue, as both a deterrence and safety measure.

DROP SAFE LOCATION:

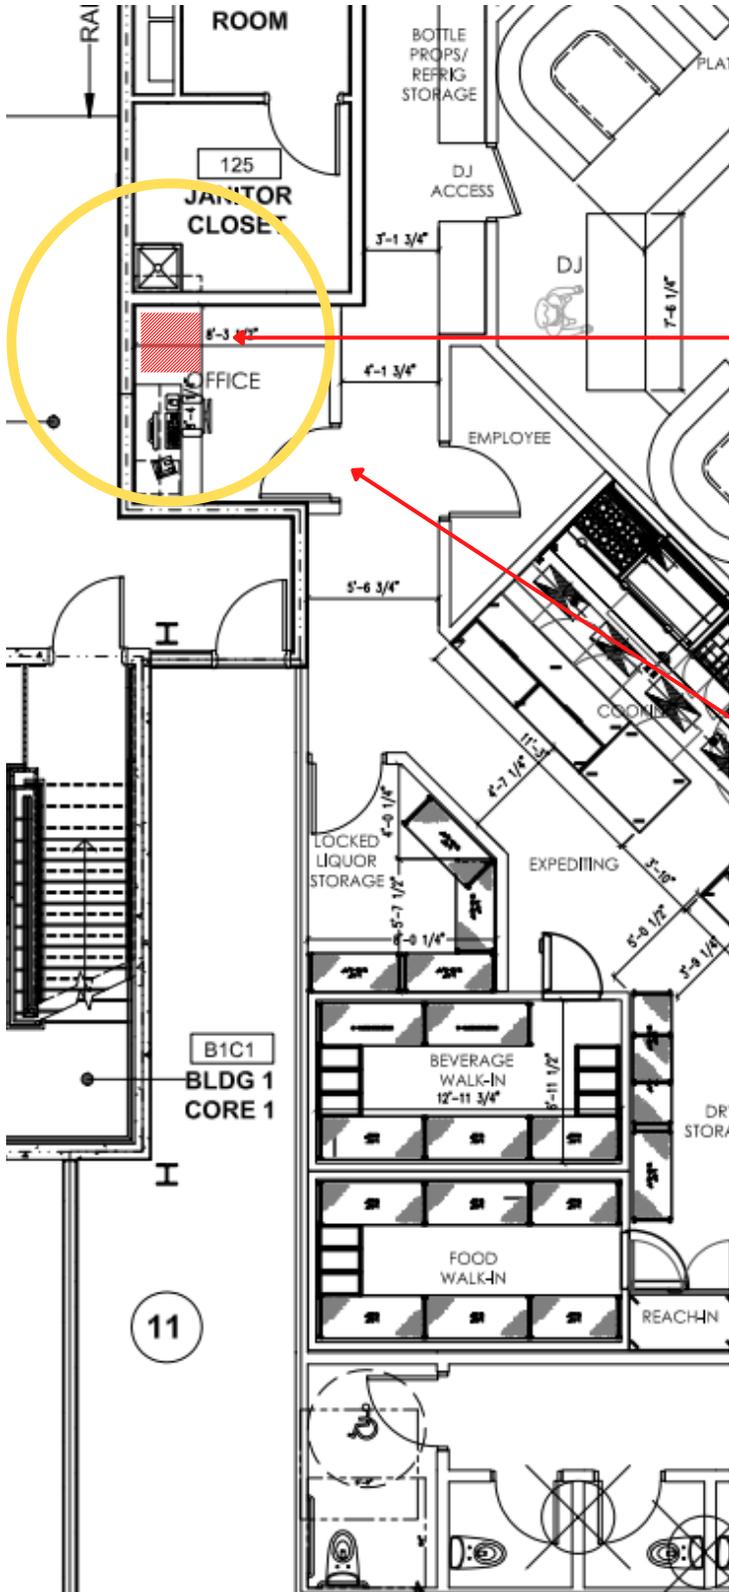

Mesa MFL3020CC BLKGR 3.6 cu ft 2 Compartment Drop Safe w/ Combination Lock

Manager Office "safe room" with Fire-rated and drill-proof steel door to house bolted down Mesa Safe.